



PLANT NORTH

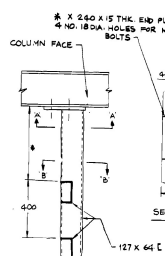


DETAIL 1
CABLE TRAY SUPPORT
(8 IN. RADIUS)

NOTE
4-DIMENSION VARY CONTRACTOR TO VERIFY FOR UNIFORM TRAY ELEVATION.

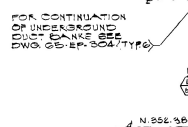

DETAIL 2

NOTE 6 (TYP)

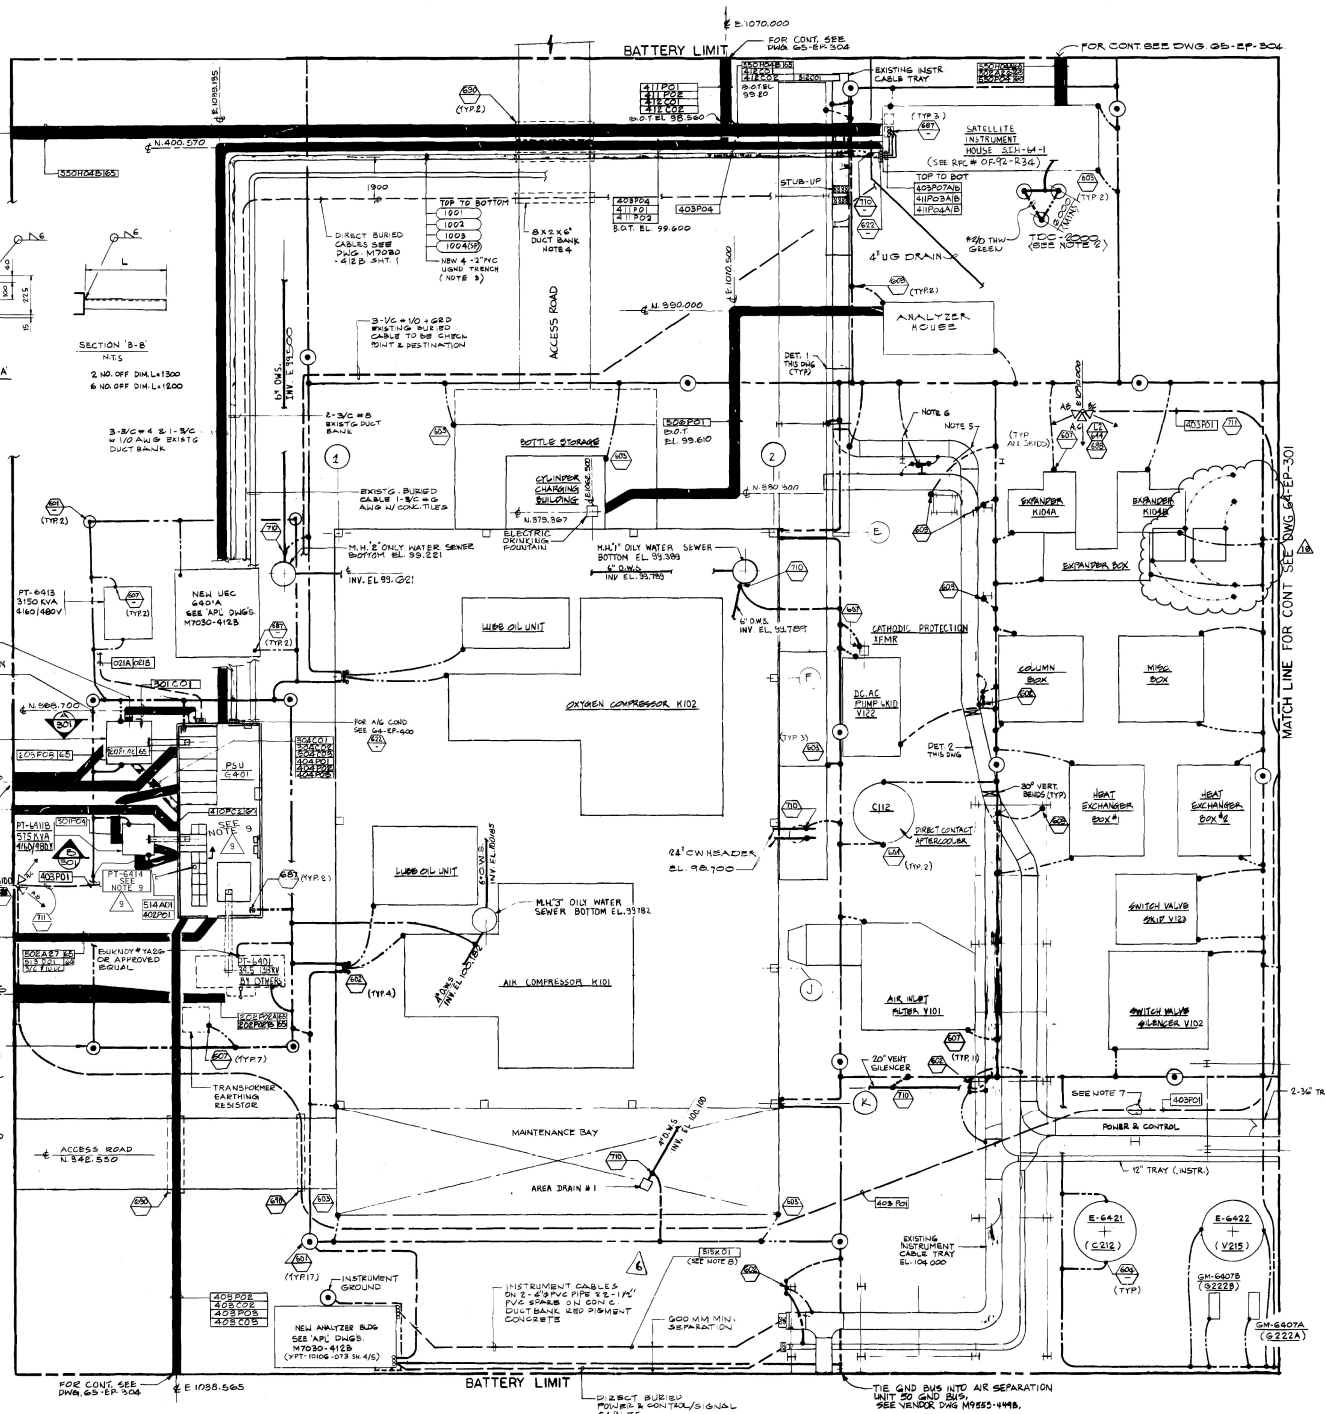

NOTES

- FOR STANDARD ELECTRICAL SYMBOLS SEE DWG 64-EP-302-2
- SEE SPECIAL INSTRUMENT GROUNDING SHALL NOT EXCEED 1 OHM RESISTANCE
- PVC CONDUIT TO BE INSTALLED 440MM MINIMUM UNDERGROUND & TO BE ENCLOSED WITH REINFORCED CONCRETE
- WORK THIS DRAWING WITH APD DRAWING NO. M7030-4128 SHT 1 THRU 5
- TYPICAL CABLE TRAY SUPPORT SEE DETAIL B ON APD DRAWING NO. M7030-803A, 20 EACH REQ'D.
- SPlice TO THE EXISTING & REMOVE THE EXISTING LIGHTING
- EXISTING INSTRUMENT CABLE TRAY SHALL BE USED IN ROUTING CABLE STRANDS TO UNIT 60 CONTROL BUILDING. SEE ENG. NOS. 80-EP-401 & 80-EP-402 FOR CONTINUATION.
- FOR UNDERGROUND & GROUNDING PLAN, SEE TYP. DWG. NO. 64-EP-331 SHT. 001.

1. SAUDI YANBU PETROCHEMICAL COMPANY

MAXIMUM CAPACITY EXPANSION

UNIT 64-AIR SEPARATION

COMBUSTION ENGINEERING

LEGEND

2. BECHTEL PETROLEUM, INC.

HOUSTON

SAUDI YANBU PETROCHEMICAL COMPANY

MAXIMUM CAPACITY EXPANSION

UNIT 64-AIR SEPARATION AREA

ELECTRICAL UNDERGROUND, GROUNDING AND LIGHTING PLAN

SHEET 1




64-EP-300

AREA

11211




64-EP-300

9

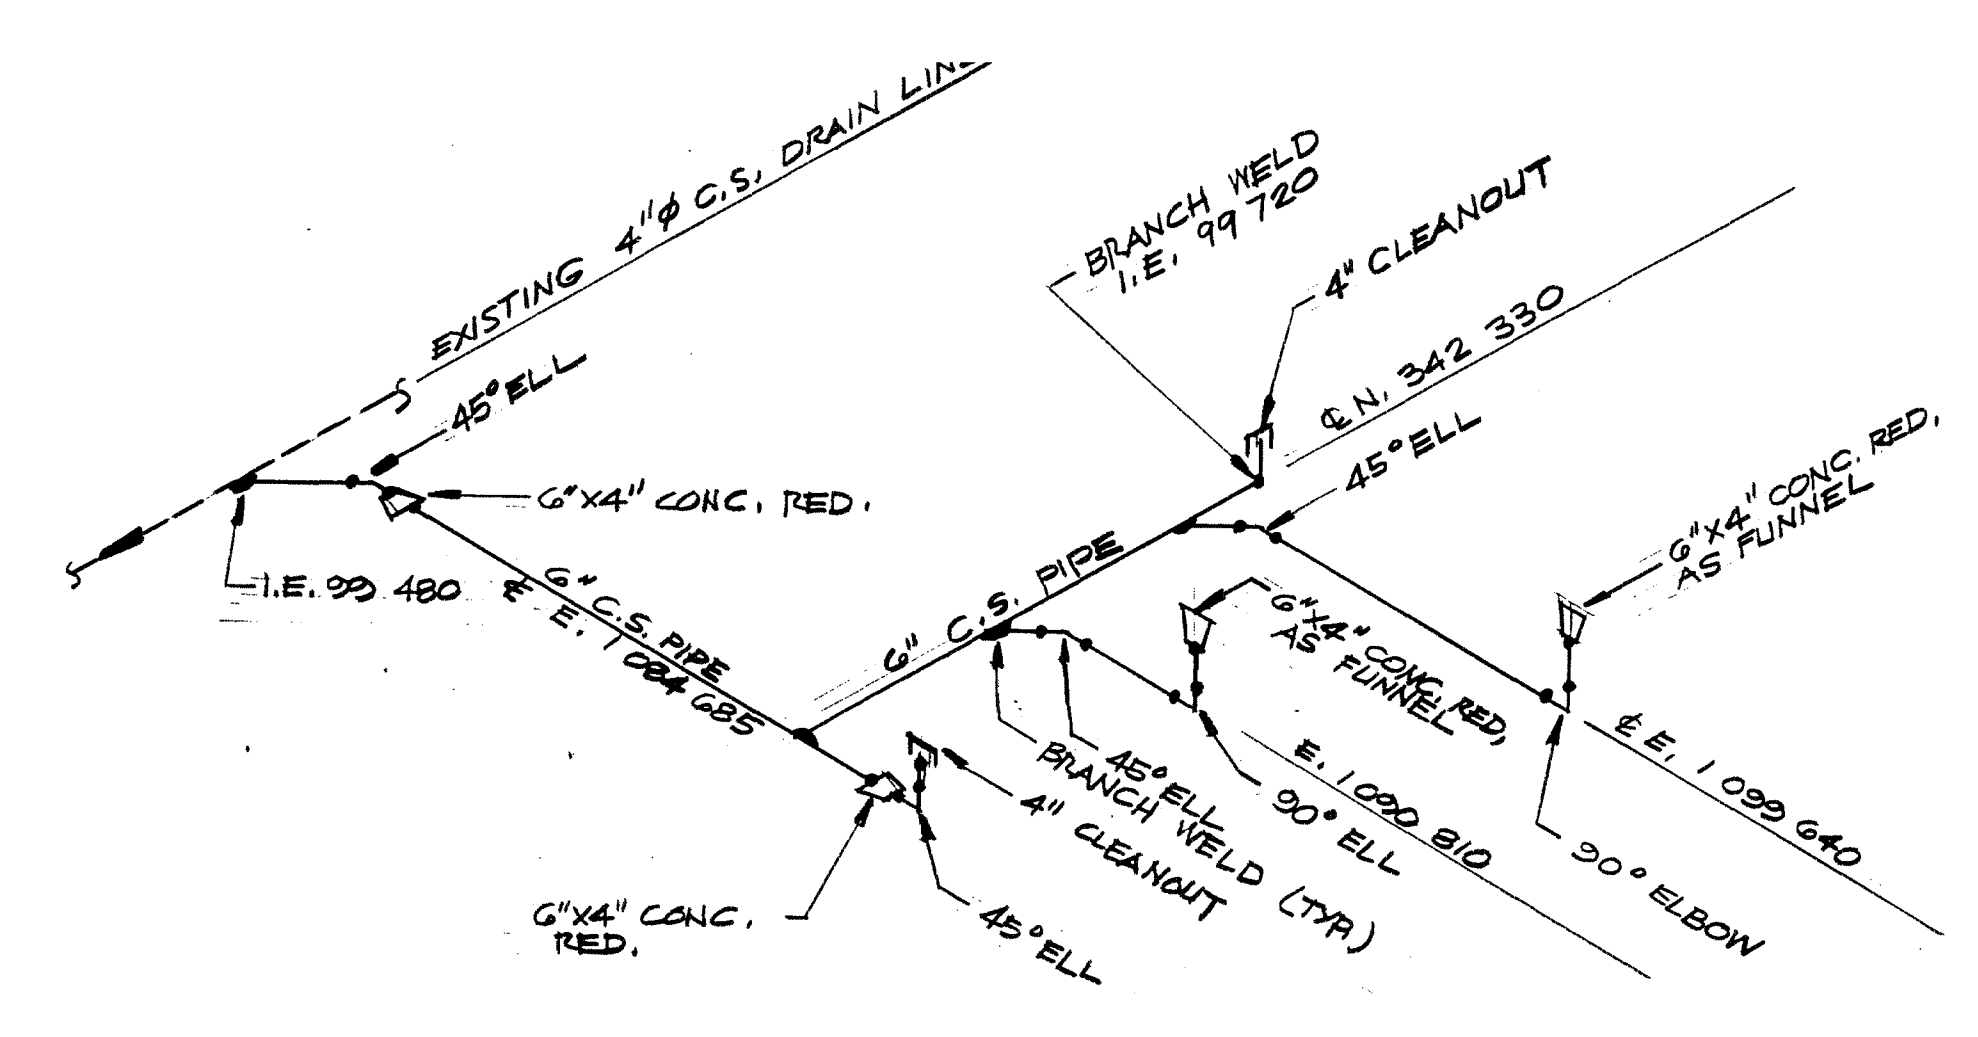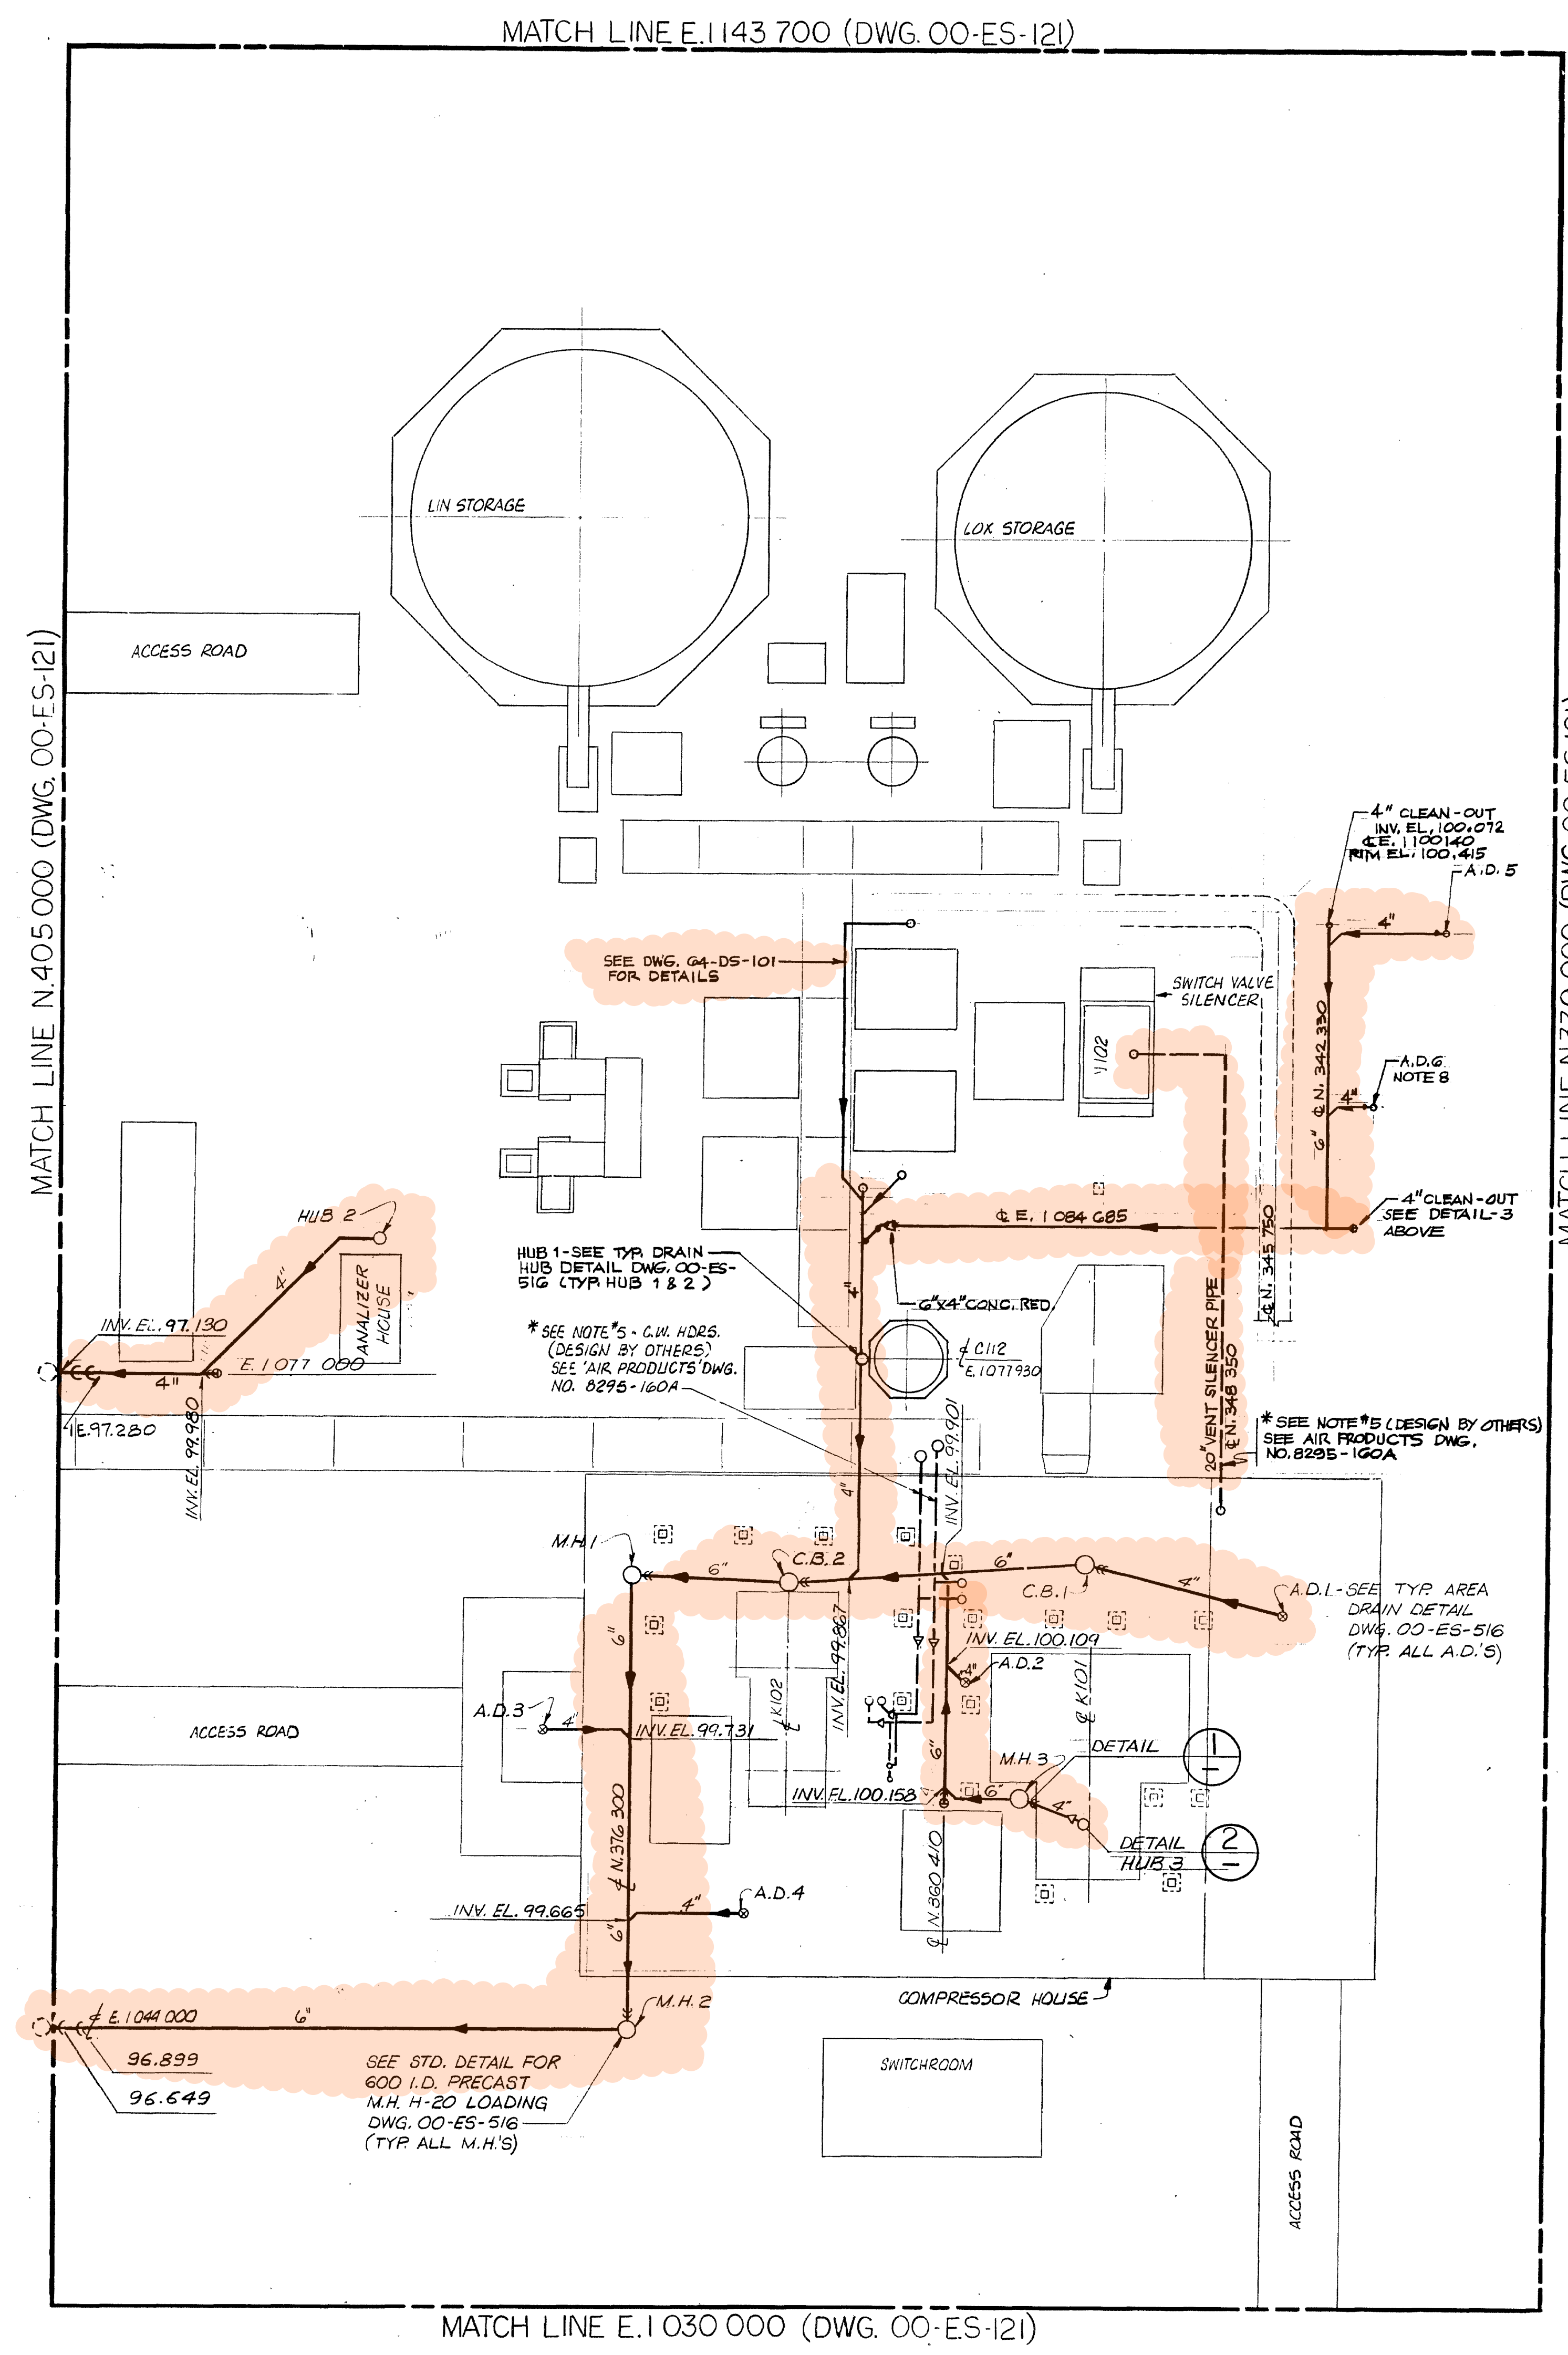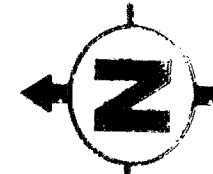

ALL INVERT ELEVATIONS INDICATED ARE BASED ON DATUM: (BECHTEL 100.50 = APL 100.00)

U/G DRAIN SYSTEM SCHEDULE									
A.D., C.B., M.H. & HUB NO.	APL DRAIN DESIGNATION	COORDINATES @ 1'		INLET INVERT EL.		COMMON SEAL INVERT EL.	OUTLET INVERT EL.	RIM ELEVATION	BOTT. OF C.B. OR M.H.
		NORTH	EAST	NORTH-SOUTH	EAST - WEST				
A.D. 1	D.P. 6	343 300	1 065 000				100.100	100.485	
A.D. 2	D.P. 1	359 310	1 061 730				100.200	100.480	
A.D. 3	D.P. 10	380 500	1 059 240				100.100	101.335	
A.D. 4	D.P. 3	370 400	1 050 000				100.100	100.450	
A.D. 5		337 285	1 039 640				100.220	100.720	
A.D. 6		340 830	1 030 810				100.175	100.494	
C.B. 1	D.P. 4	353 260	1 067 300	100.00		99.650	99.950	100.450	99.500
C.B. 2	D.P. 2	368 400	1 066 680	99.845		99.595	99.845	100.485	99.443
M.H. 1	NONE	376 300	1 067 300	99.789		99.539	99.789	100.300	99.389
M.H. 2	NONE	376 300	1 044 000		99.621	99.371	99.621	99.890	99.221
M.H. 3	NONE	356 510	1 055 760	100.162		99.932	100.165	100.500	99.732
HUB 1	D.P. 8	364 775	1 077 930				100.245		
HUB 2	D.P. 12	367 950	1 084 050			99.900	100.100		
HUB 3	D.P. 5	353 260	1 054 545				100.212		

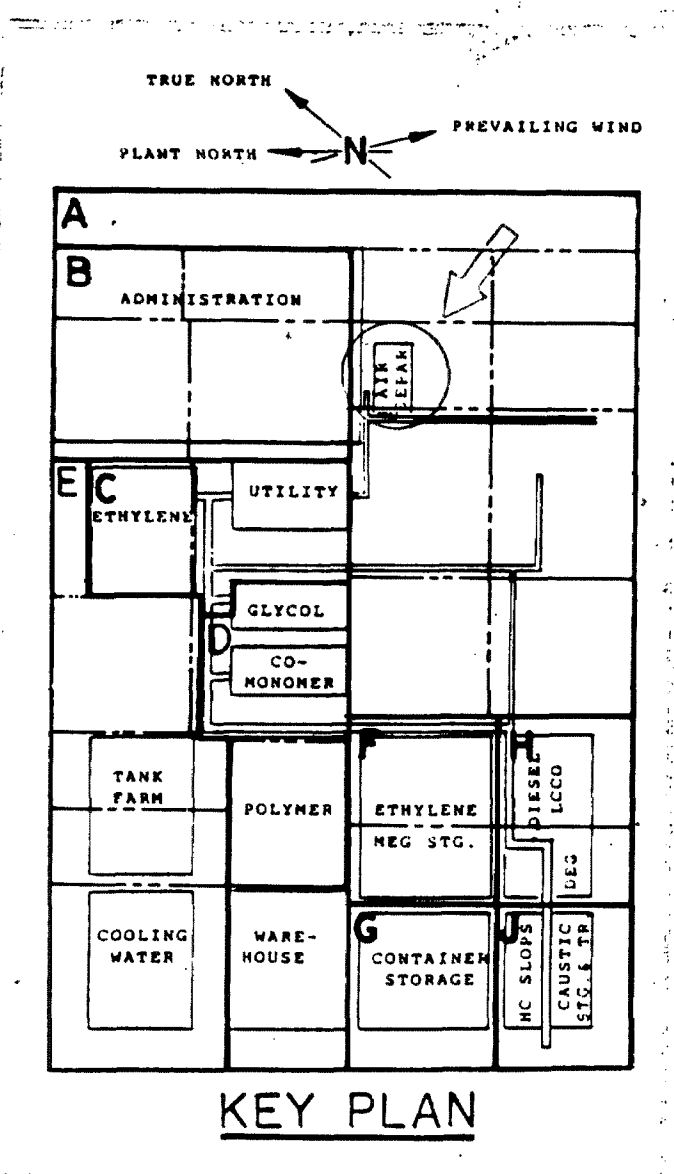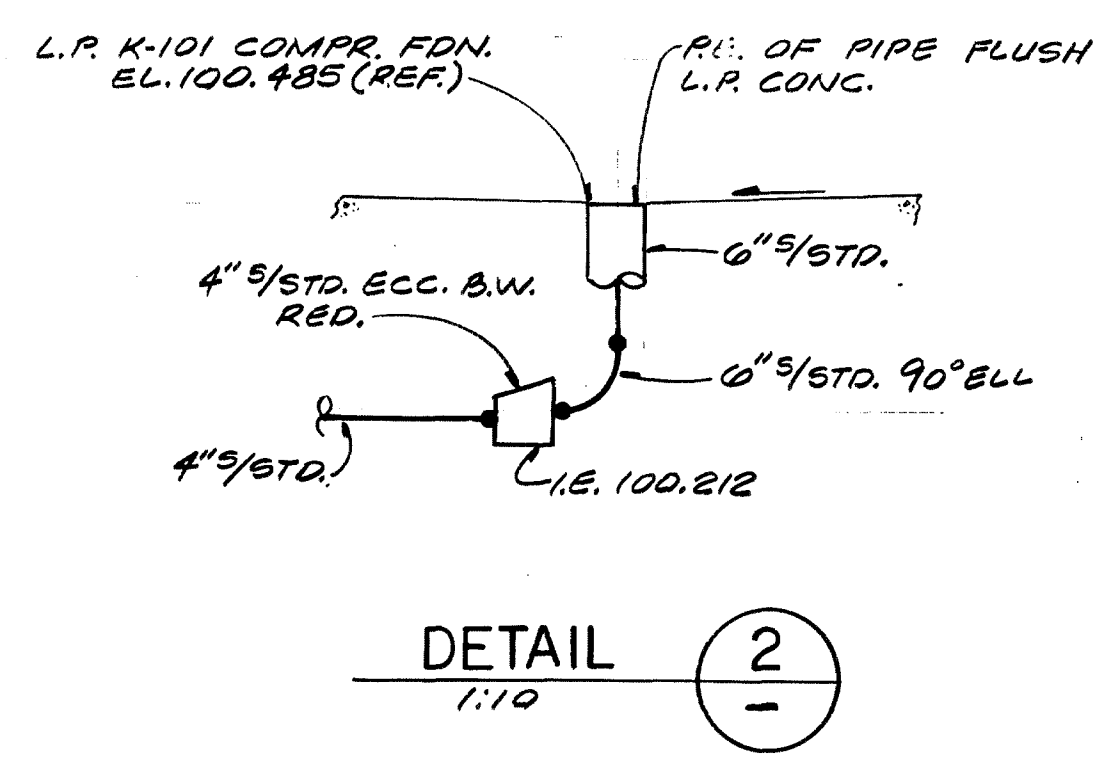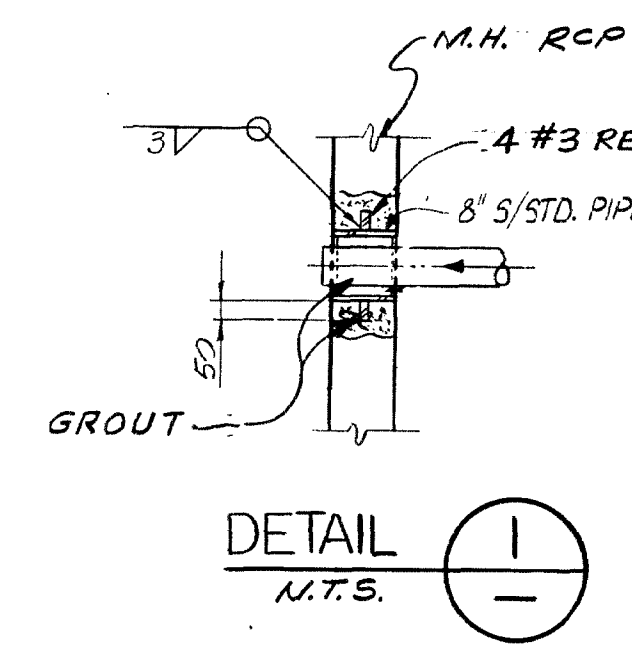

LIST OF MATERIAL			ITEM QUAN.		DESCRIPTION		ORDER NO.	
1	3	CU METERS CONCRETE R ₂ = 21 MPa					000-2-001	
2		REINFORCING STEEL					000-Q-020	
		NO. 3	4	5	6			
3	17	CONCO STD. RCP 600 I.D. x 300 L.G. SEC.					000-5-320	
4	2	RICHARD FOUNDRY "A2250 FRAME 8"					000-5-314	
5	3	RICHARD FOUNDRY "A-2658 FRAME 5"					000-5-314	
6	EA	SOLID COVER ASTM A-48 CL-30 H-20 LOADING					000-M-010	
7	10 L.M.	4" PIPE - C&W BE X5 CS API-5L-B SMLS						
8	40 L.M.	6" PIPE - C&W BE X5 CS API-5L-B SMLS						
9	2 EA	90° LR ELL BN STD CS A234-WPB (WFC05)						
10	1 EA	45° LR ELL BN STD CS A234-WPB (WFC05)						
11	3 EA	4" 90° CONC. RED. BN STD CS A234						
12	2 EA	4" IPS THREAD BRASS PLUG W/CSK HEAD (FLUSH W/ RAVING)						
13	2 EA	4" CS CPLG 300 THD. MI 187 GALV.						

NOTE: FOR "L" CATEGORY PIPING, SEE SCREEN PRODUCED LIST OF MATERIAL FOR THIS DWG.

- GENERAL NOTES
1. COMP. HOUSE H.P. FINISH: D FLR. EL. = 100.50
 2. ALL DIMENSIONS SHOWN ARE IN MILLIMETERS. ALL ELEVATIONS ARE IN METERS. ALL PIPE SIZES ARE IN INCHES.
 3. FOR GENERAL NOTES AND LEGEND SEE DWG. 00-ES-126
 4. ALL HORIZONTAL AND VERTICAL PIPING BENDS TO BE 45° UNID.
 5. DESIGN OF PIPING PER AIR PRODUCTS LTD. - ENGLAND. MATERIAL FURNISHED BY BECHTEL INC. PER CONFERENCE NOTES C-1650 & 1022
 6. ALL PIPE & FITTINGS ARE REFERENCED TO SPECIFICATION L-1, CD-20 (U.O.N)
 7. ALL UNDERGROUND PIPE AND FITTINGS TO BE COATED AND WRAPPED PER SPEC. L-11
 8. USE 6" X 4" CONC. RED. AS FUNNEL.

REFERENCE DRAWINGS		
UNDERGROUND PIPING KEY PLAN		00-ES-126
TYPICAL UNDERGROUND DETAILS		00-ES-126
AIR PRODUCTS "T-1" 1/2" PIPING ISO DETAIL		8295-1004
AIR PRODUCTS DWG. - COND. HOUSE FLOOR PLAN, SHIFTS 3 & 4		MB295-11204
AIR PRODUCTS DWG. - PIPE RACK & PLATFORM FND DETAIL		MB295-1303
AIR PRODUCTS DWG. - DCA AC-112 PUMP SKID FND DET.		MB295-1434
AIR PRODUCTS DWG. - FND LAYOUT SHIT. 1 & 2		MB295-1504
AIR PRODUCTS DWG. - TRANSFORMER & ANALYZER BLDG SHIT. 1		MB295-1444
DEMAN DWG. - CONDENSATE OUTLET DETAIL		05509/15
UNDERGROUND PIPING PLAN UNIT-02		00-ES-121
ELECT. UNGD. GROUNDING AND LIGHTING PLAN		04-EP-300
UNGD. ELECT. CONDUIT CABLE LAYOUT		8295-1004



REVISIONS									
NO.	DATE	REVISIONS	BY	CHKD	DESIGNED	DRAWN	INSTR	APPV	
1	7/1/05	REVISED COORDINATES TO N. 342.400 WAS 343.150.	ACC						
2	7/1/05	ADDED AD. 5 & 6 AND SEWER PIPE LOCATING PER PROJECT NO.	ACC						
3	7/1/05	REVIEWED AS-BUILT, NO CHANGES	ACC						
4	7/1/05	REN. KEY PLAN & DETAIL "1"; ADDED SEWER & DELETED "1" DETAIL	ACC						
5	7/1/05	REVISED DETAIL "1" LIST OF MATERIAL REV. ELEV.	ACC						
6	7/1/05	REVISED ELEVATIONS	ACC						
7	7/1/05	AS-BUILT PER PROJECT	ACC						
8	7/1/05	ISSUED FOR CONSTRUCTION	ACC						

BECHTEL PETROCHEMICAL, INC.
HOUSTON

SAUDI YANBU PETROCHEMICAL COMPANY

UNDERGROUND PIPING
PLAN, SECTIONS AND DETAILS
UNIT 64: AIR SEPARATION

AREA	11211	DATE	64-ES-100	9
------	-------	------	-----------	---

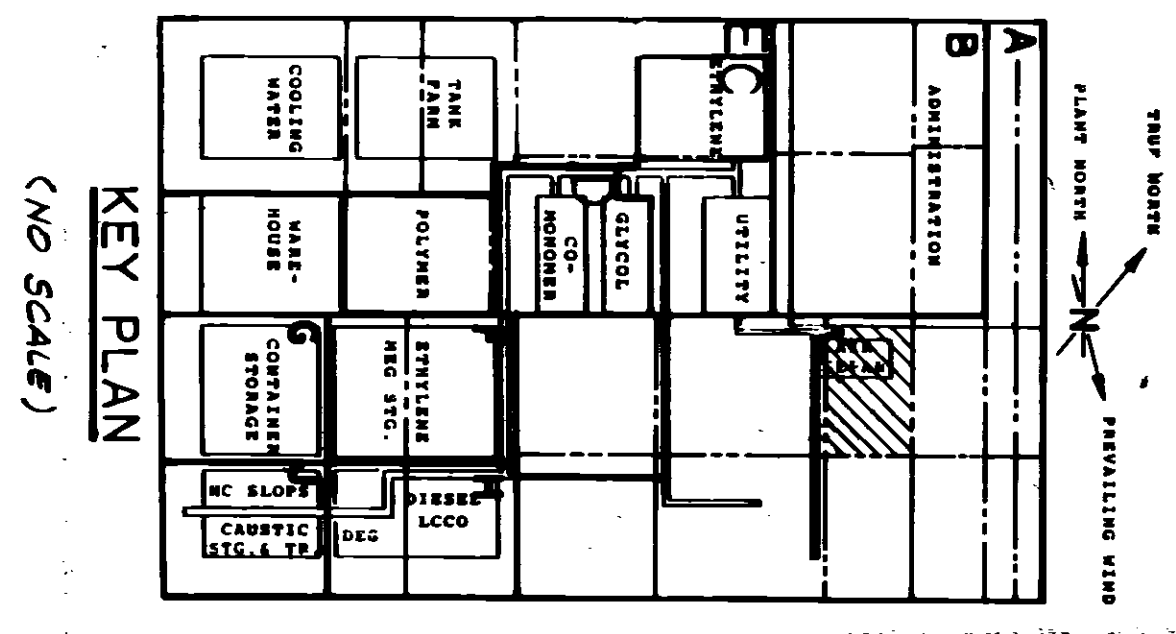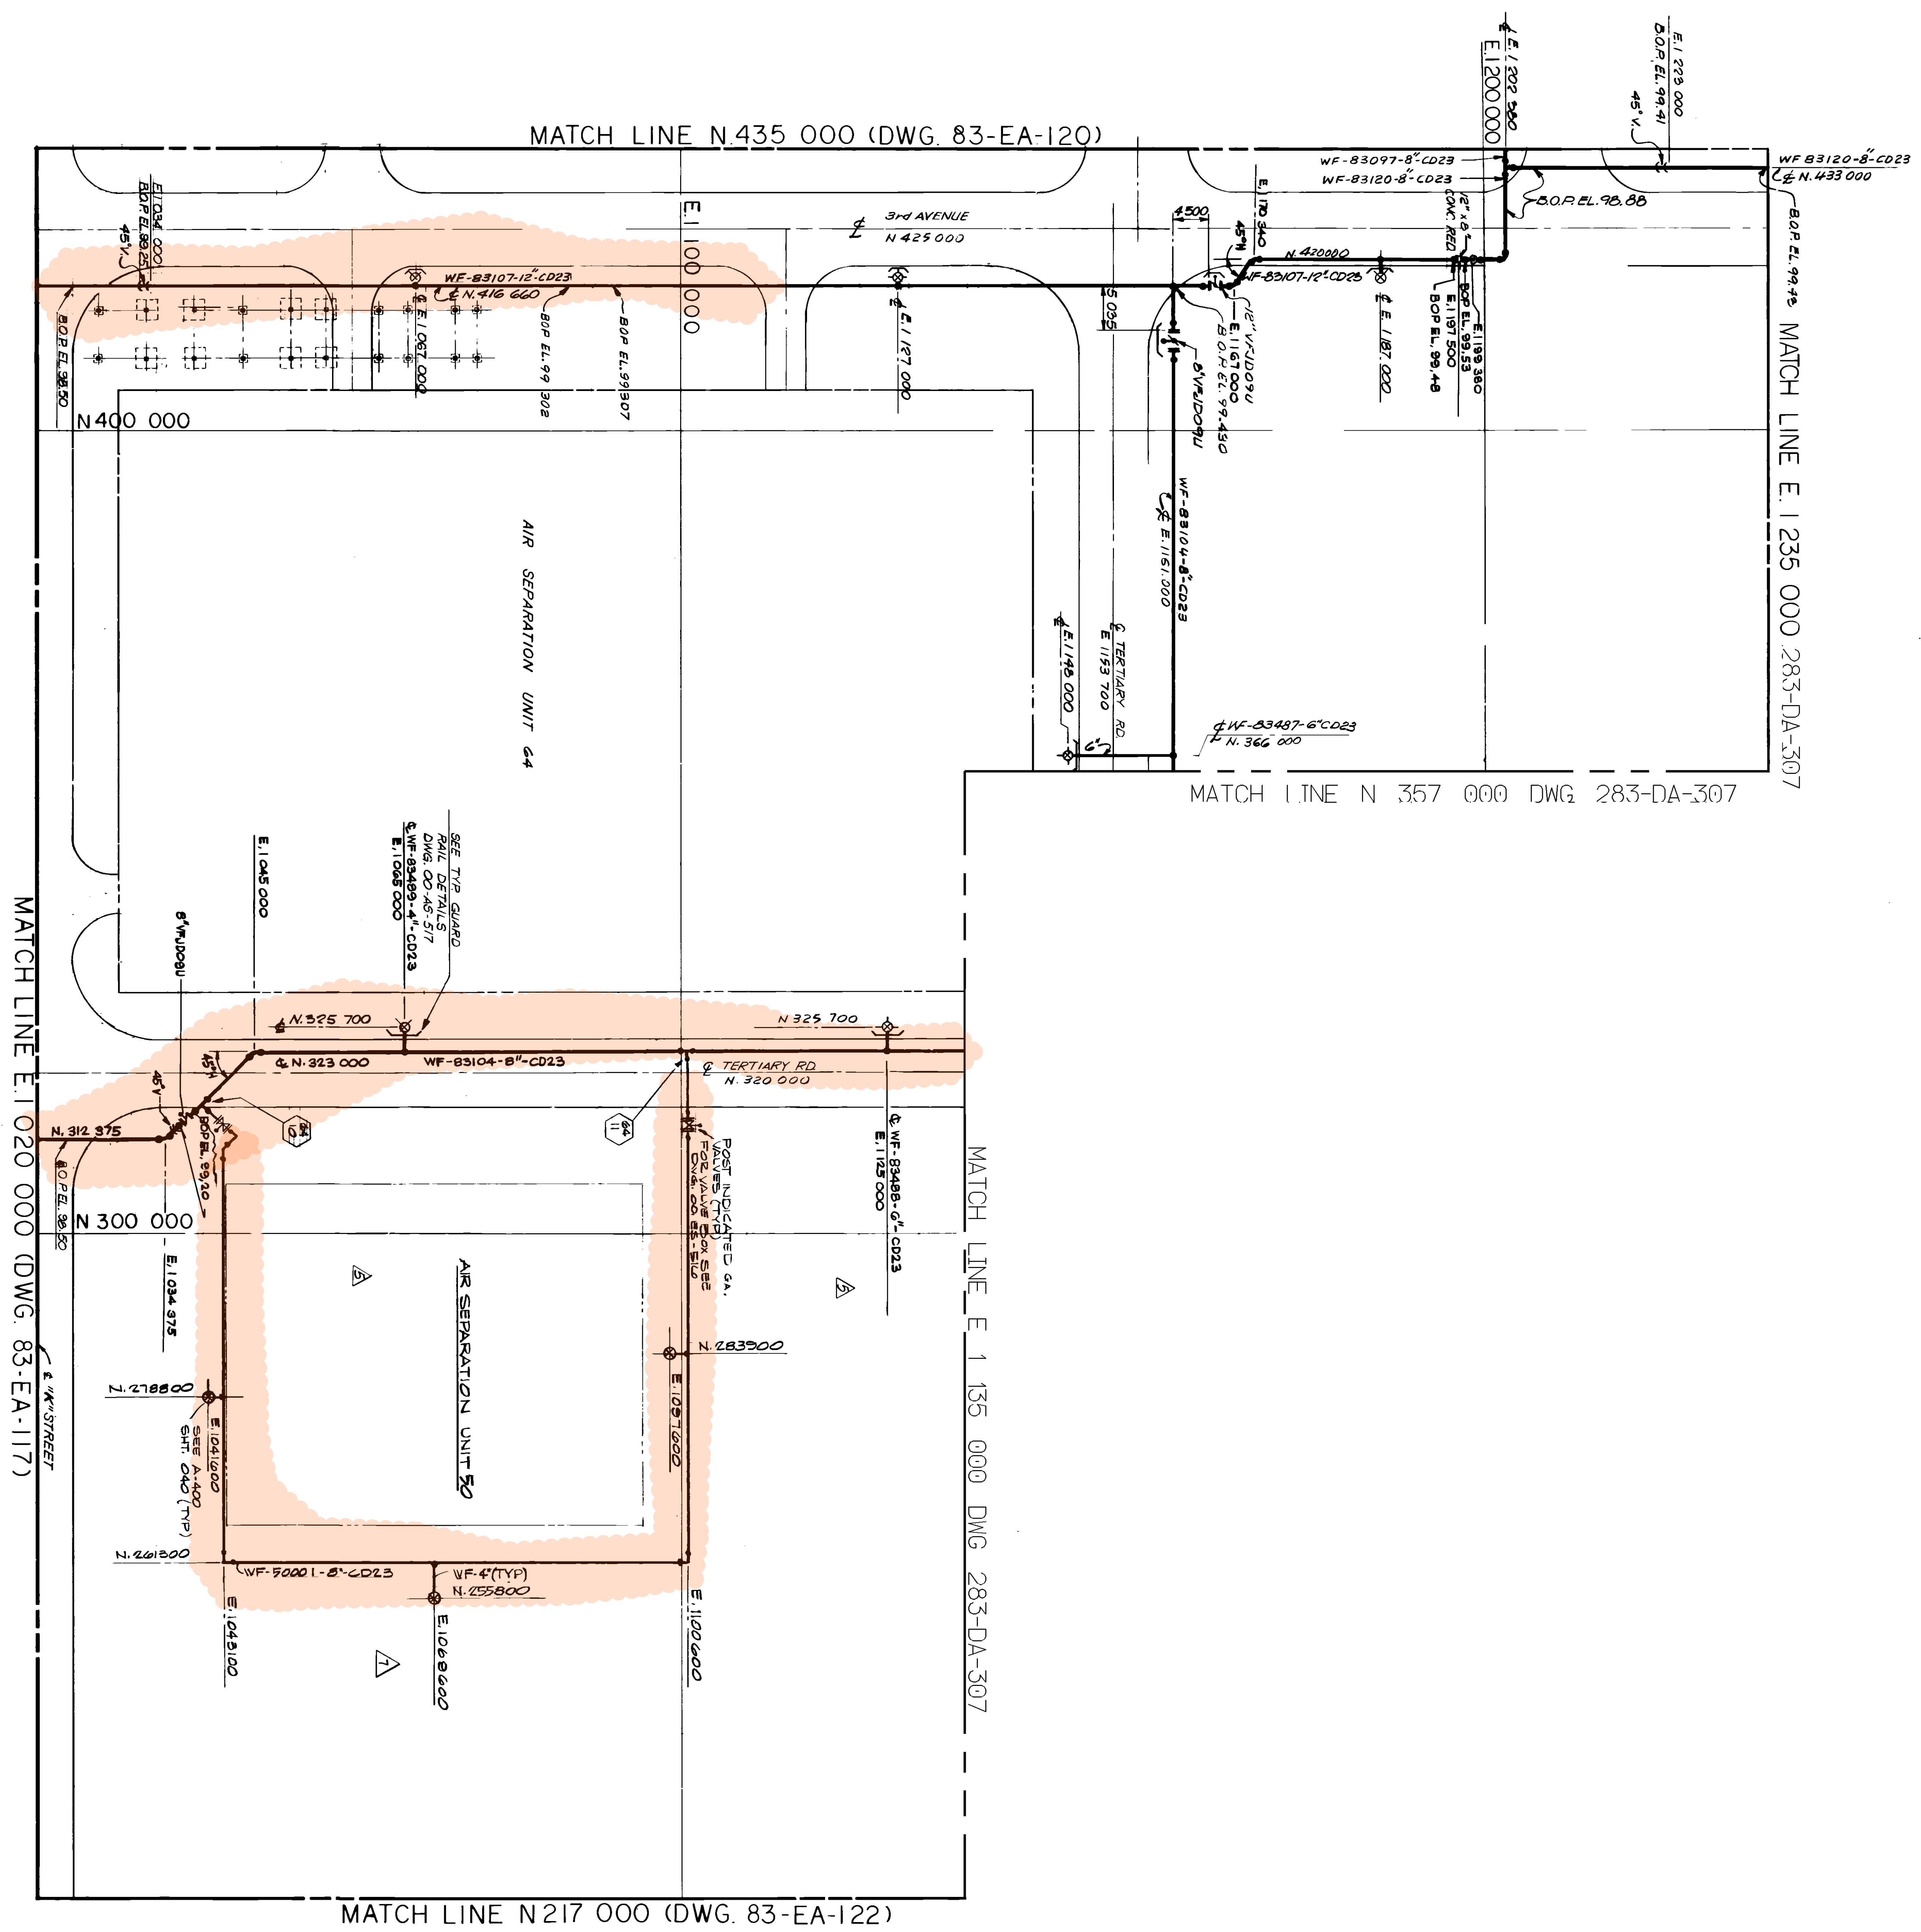

LIST OF MATERIAL

ITEM QUAN	DESCRIPTION	ORDEN NO
1	2 6 CO METERS CONC FC-21 W20	000 2-004
2	1107 L CATEGORY PIPING	

NOTES

1. FOR GENERAL NOTES & LEGEND SEE DWG. 83-EA-120
2. FOR CATEGORY PIPING SEE SCREEN 2
3. PRODUCED LIST OF MATERIALS FOR THIS DWG.

REFERENCE DRAWINGS

OVERALL FIREWATER KEY PLAN	03-DA-127
OVERALL UNDERGROUND PIPING PLAN	00-DA-128
ELEC. UNDO. RACEWAY & GROVE PLAN	05-DA-304
ROT. PLAN AREA & AIR SEPARATION & FLARE	00-DA-307
GRAND RAIL DETAILS	00-DA-371

SAUDI YANBU PETROCHEMICAL COMPANY
MAXIMUM CAPACITY EXPANSION


NO.	DESCRIPTION	QTY	UNIT	REMARKS
1	PIPE	100	FT	
2	VALVE	10	PCS	
3	FLANGE	20	PCS	
4	WELDING	100	FT	
5	PAINT	100	FT	
6	LABOR	100	FT	
7	MATERIAL	100	FT	
8	WATER	100	FT	
9	ELECTRICITY	100	FT	
10	TELEPHONE	100	FT	
11	POSTAGE	100	FT	
12	TRAVEL	100	FT	
13	FOOD	100	FT	
14	DRINKING	100	FT	
15	TOILET	100	FT	
16	SHOWER	100	FT	
17	BATH	100	FT	
18	KITCHEN	100	FT	
19	DINING	100	FT	
20	SLEEPING	100	FT	
21	STORAGE	100	FT	
22	WORKSHOP	100	FT	
23	OFFICE	100	FT	
24	RECEPTION	100	FT	
25	ENTRANCE	100	FT	
26	EXIT	100	FT	
27	STAIR	100	FT	
28	ELEVATOR	100	FT	
29	ROOF	100	FT	
30	FLOOR	100	FT	
31	WALL	100	FT	
32	CEILING	100	FT	
33	DOOR	100	FT	
34	WINDOW	100	FT	
35	SCREEN	100	FT	
36	SHUTTER	100	FT	
37	BLIND	100	FT	
38	SLAT	100	FT	
39	TRAILER	100	FT	
40	TRUCK	100	FT	
41	BUS	100	FT	
42	TAXI	100	FT	
43	CAR	100	FT	
44	BOAT	100	FT	
45	SHIP	100	FT	
46	PLANE	100	FT	
47	TRAIN	100	FT	
48	WAGON	100	FT	
49	TRAM	100	FT	
50	MONORAIL	100	FT	
51	CONVEYOR	100	FT	
52	CRANE	100	FT	
53	LIFT	100	FT	
54	HOIST	100	FT	
55	CABLE	100	FT	
56	WIRE	100	FT	
57	PIPE	100	FT	
58	VALVE	100	FT	
59	FLANGE	100	FT	
60	WELDING	100	FT	
61	PAINT	100	FT	
62	LABOR	100	FT	
63	MATERIAL	100	FT	
64	WATER	100	FT	
65	ELECTRICITY	100	FT	
66	TELEPHONE	100	FT	
67	POSTAGE	100	FT	
68	TRAVEL	100	FT	
69	FOOD	100	FT	
70	DRINKING	100	FT	
71	TOILET	100	FT	
72	SHOWER	100	FT	
73	BATH	100	FT	
74	KITCHEN	100	FT	
75	DINING	100	FT	
76	SLEEPING	100	FT	
77	STORAGE	100	FT	
78	WORKSHOP	100	FT	
79	OFFICE	100	FT	
80	RECEPTION	100	FT	
81	ENTRANCE	100	FT	
82	EXIT	100	FT	
83	STAIR	100	FT	
84	ELEVATOR	100	FT	
85	ROOF	100	FT	
86	FLOOR	100	FT	
87	WALL	100	FT	
88	CEILING	100	FT	
89	DOOR	100	FT	
90	WINDOW	100	FT	
91	SCREEN	100	FT	
92	SHUTTER	100	FT	
93	BLIND	100	FT	
94	SLAT	100	FT	
95	TRAILER	100	FT	
96	TRUCK	100	FT	
97	BUS	100	FT	
98	TAXI	100	FT	
99	CAR	100	FT	
100	BOAT	100	FT	

BECHTEL PETROLEUM, INC.

SAUDI YANBU PETROCHEMICAL COMPANY

FIREWATER PLAN
UNIT 83 FIRE PROTECTION SYSTEM


AREA	NO.	DESCRIPTION	QTY
A	11211	83-EA-121	7

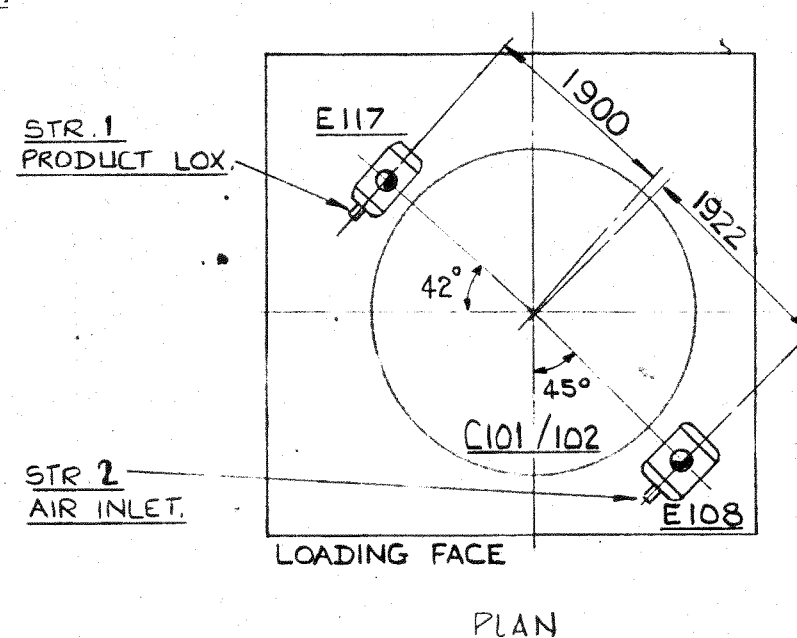

1- APL DATUM ELEVATION 100.000
= PLANT SITE ELEVATION 100.500
(HUNTING SURVEY EL. 5.25 M).

BECHTEL
HOUSTON
SAUDI YANBU
PETROCHEMICAL COMPANY
M/R 11211-64-A-1
DWG NO. _____

					SCALE: —	AIR PRODUCTS LTD.	
					DRAWN: A.M.C.		
					CHECKED: T.G.V.	COLUMN BOX EQUIPMENT	
1	SEE ECN 11724	16/4/82	TGV	<i>[Signature]</i>	APPROVED: <i>W. Hap</i>	—	
0	ORIGINAL ISSUE	25/3/82	A.M.C.	TGV	DATED 25/3/82	ARRANGEMENT.	
P	PRELIMINARY ISSUE	21/10/81	A.M.C.				
No.	DESCRIPTION	DATE	BY	CHK.		DRAWING No. 8295 - 615D	
REVISIONS							SHEET 1 OF 1

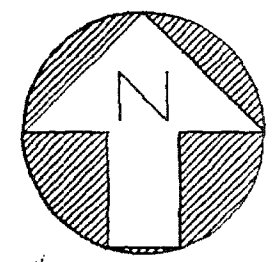

K1 N 343200

M N 337200

N N 331200


8D N 328450

MATCHLINE COD M7030-3120A E 1105850

DRAWING LIMIT N 343200

PLOT LIMIT N 330000

DRAWING LIMIT N 327600

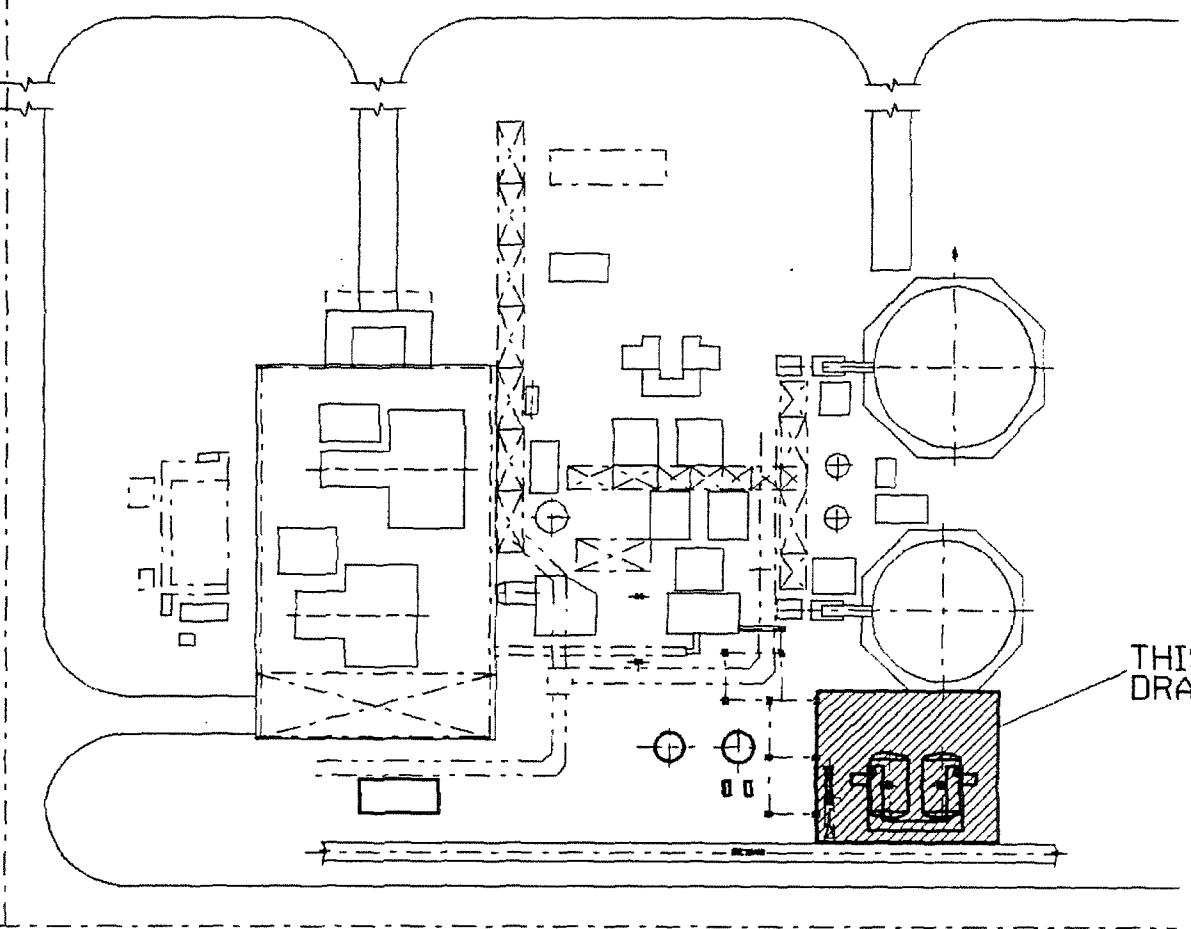

KEY PLAN

REFERENCE DRAWINGS

M8295-10B	PLOT PLAN
M8295-12A	EQUIPMENT ARRANGEMENT

NOTES

- FOR ALL OTHER REFERENCE DRAWINGS SEE ISOMETRIC FRONT SHEET M7030-3111D.
- ELEVATIONS ON THIS DRAWING ARE TO APL DATUM 100000 = 100500 PLANT SITE ELEVATION.
- SECTIONS A-A & B-B SHOWN ON THIS DRAWING REFER TO DETAILS ON DRAWINGS M7030-3110A SHT 3 & M7030-3110A SHT 2 RESPECTIVELY.

RED = ORIGINAL
DO NOT DESTROY

BATCH REF: - AR-W/MSBX/SITE


REV	ECN	REVISIONS	DATE	DRAWN	CHKD	APPD
1	18932	SEE ECN	2-10-91	BTS	IC	
0		ORIGINAL ISSUE	26-7-91	MUG	LCA	IRC
P		PRELIMINARY ISSUE	MAY 91	JSH		

THIS DRAWING IS THE PROPERTY OF AIR PRODUCTS PLC AND ITS SUBSIDIARIES. IT MUST NOT BE REPRODUCED OR USED FOR PURPOSES OTHER THAN THAT FOR WHICH IT WAS SUPPLIED.

PIPING GENERAL ARRANGEMENT
MOLECULAR SIEVE AREA
YANBU - SAUDI ARABIA

AIR PRODUCTS YPT-10106-019


DRAWN: JSH	DATE: MAY 91	DWG NO: M7030-3110A	SHEET 1 OF 3
CHECKED: SB	SCALE: 1:25	APPROVED: J. HOLDER	


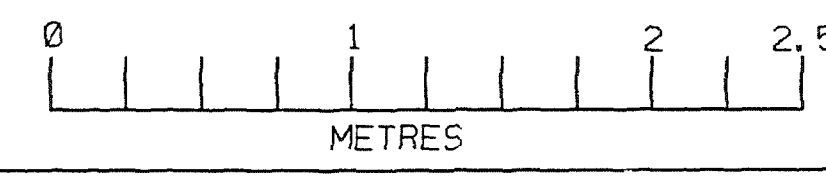


YPT-10106-019 SHT.1 OF 3


YPT-10106-019 SHT.1 OF 3

FILE NAME: - 3110A01.DGN

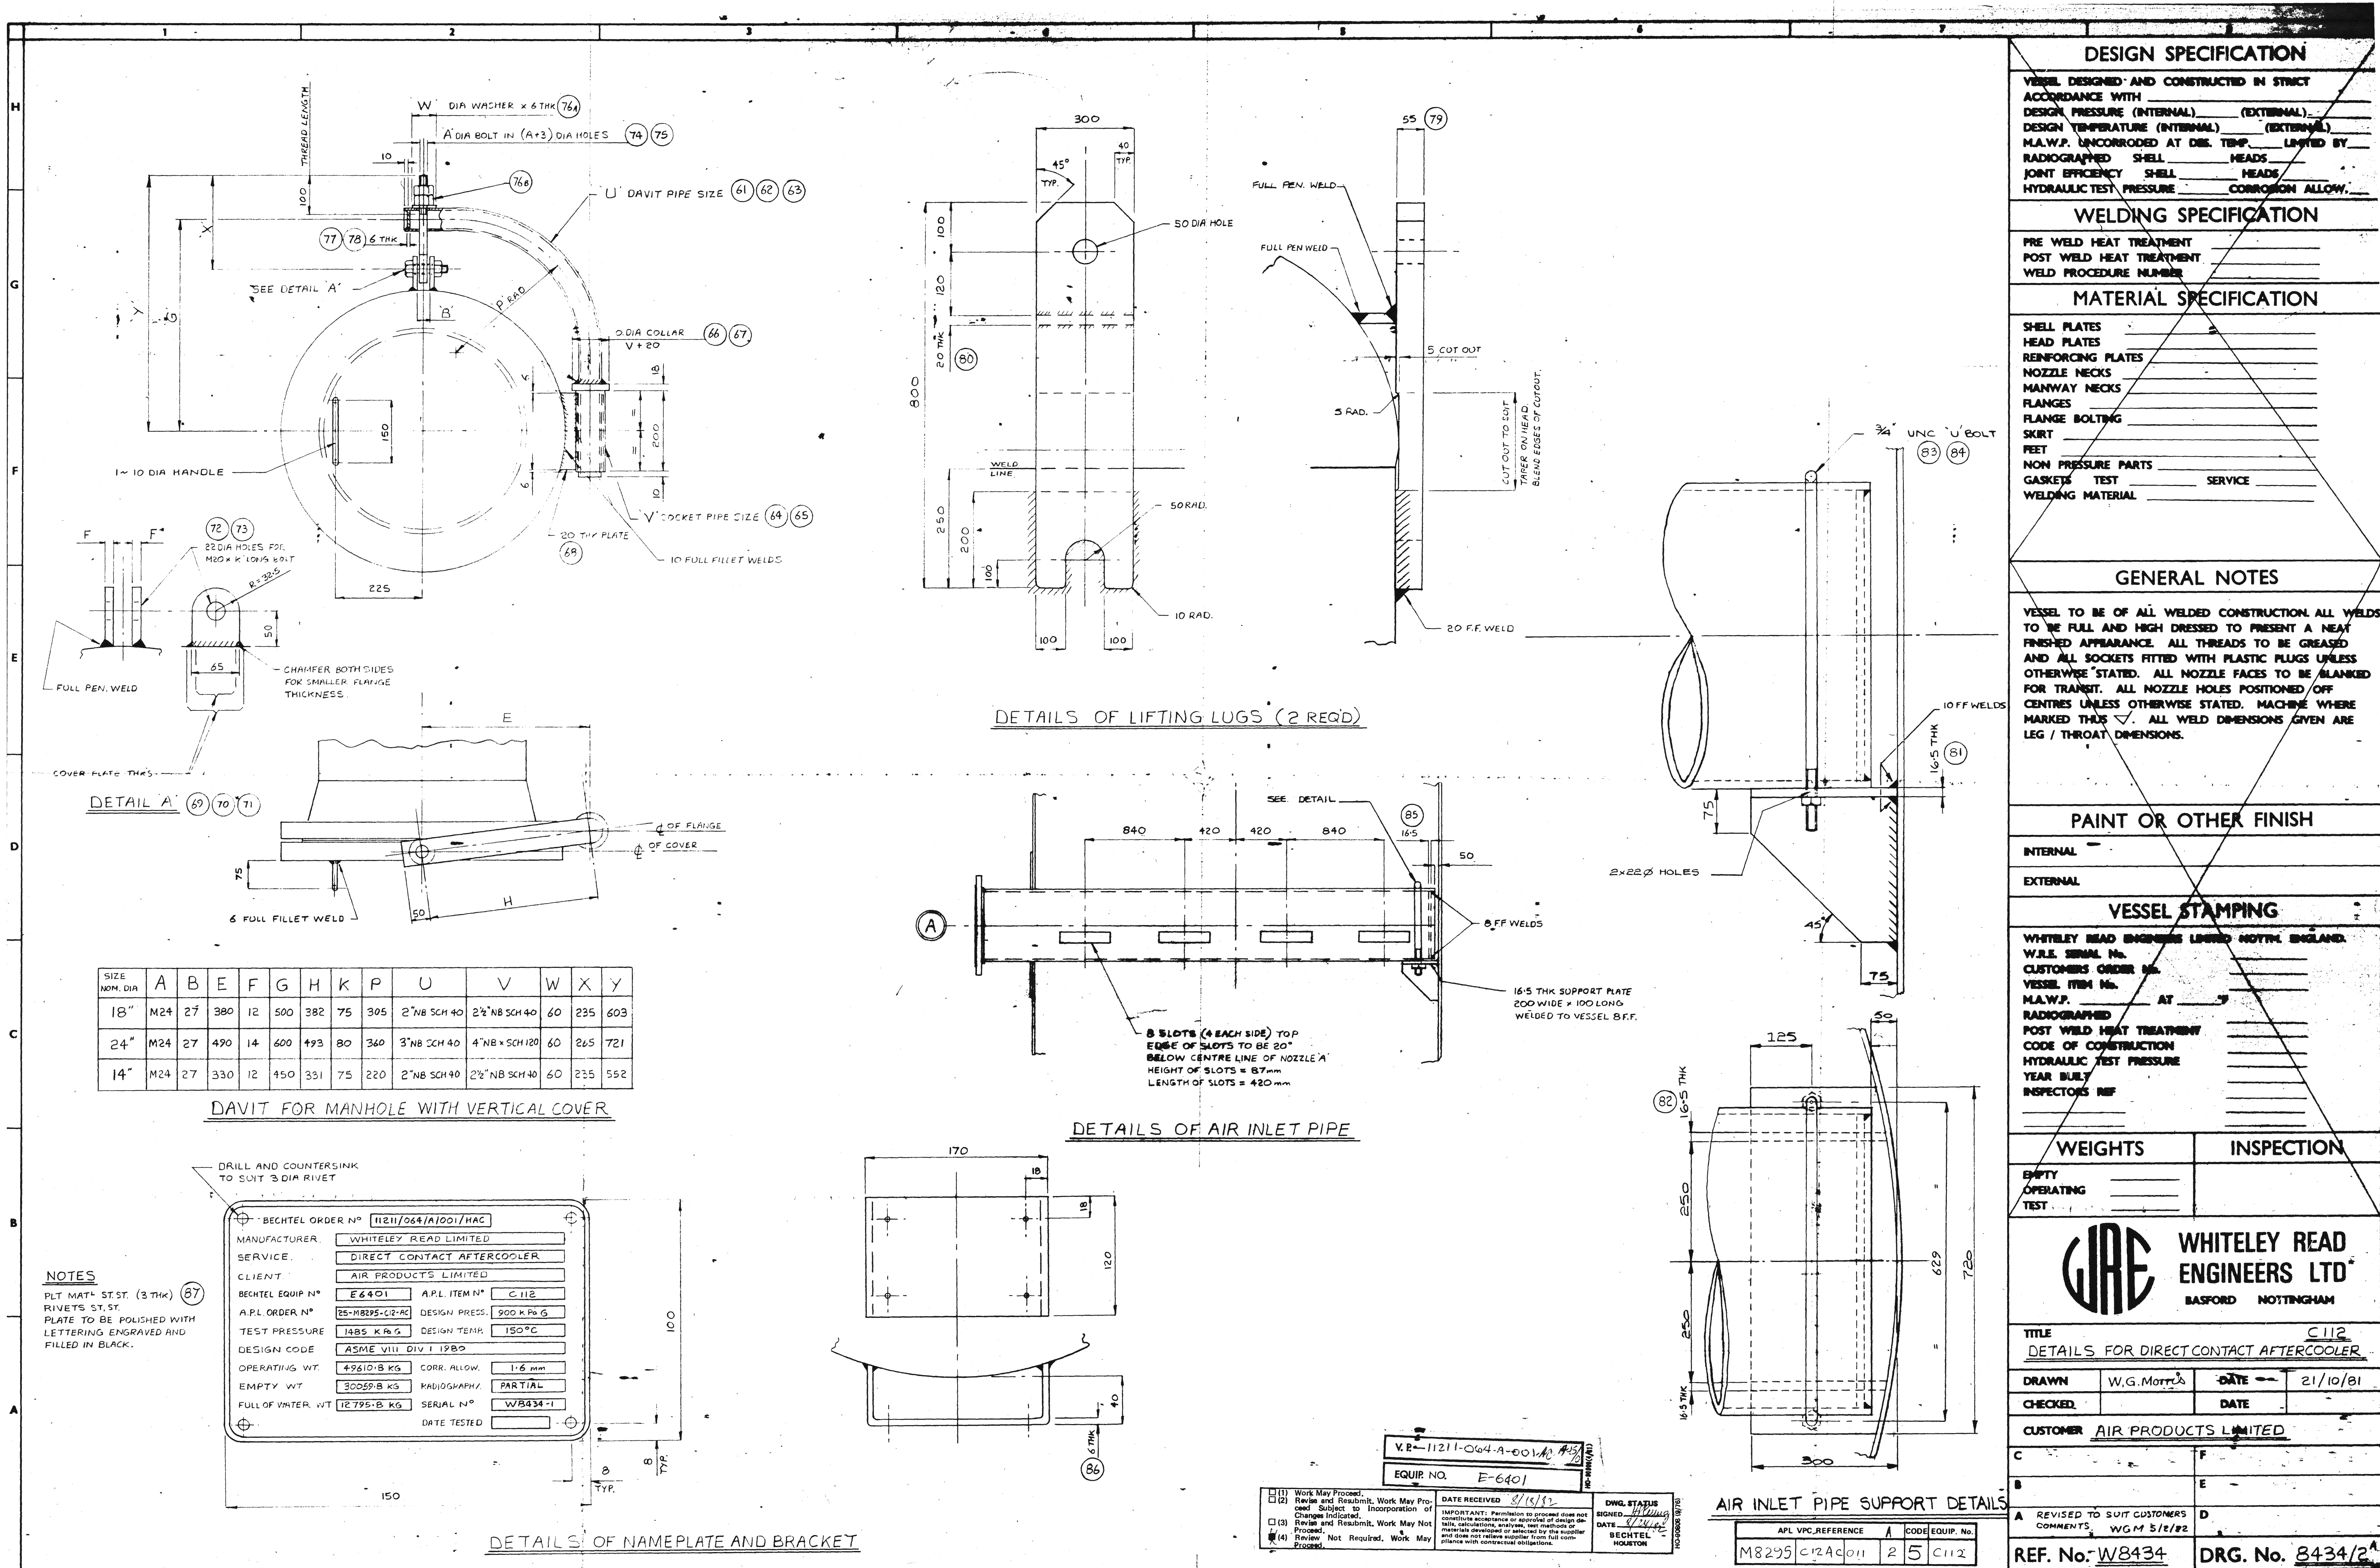


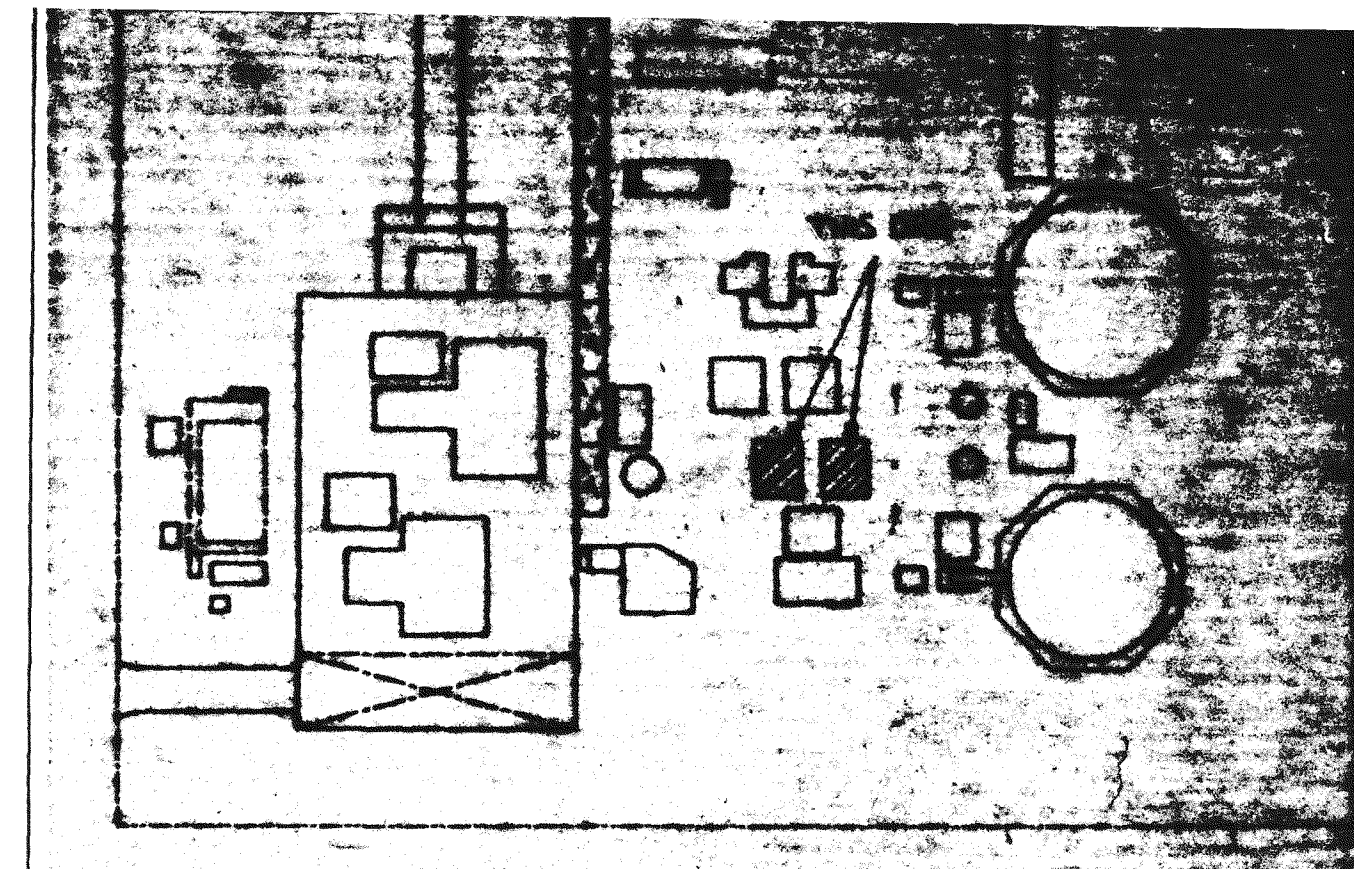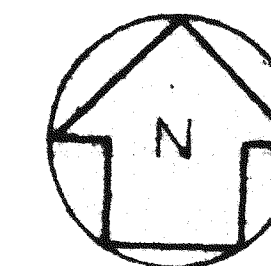

KEY PLAN

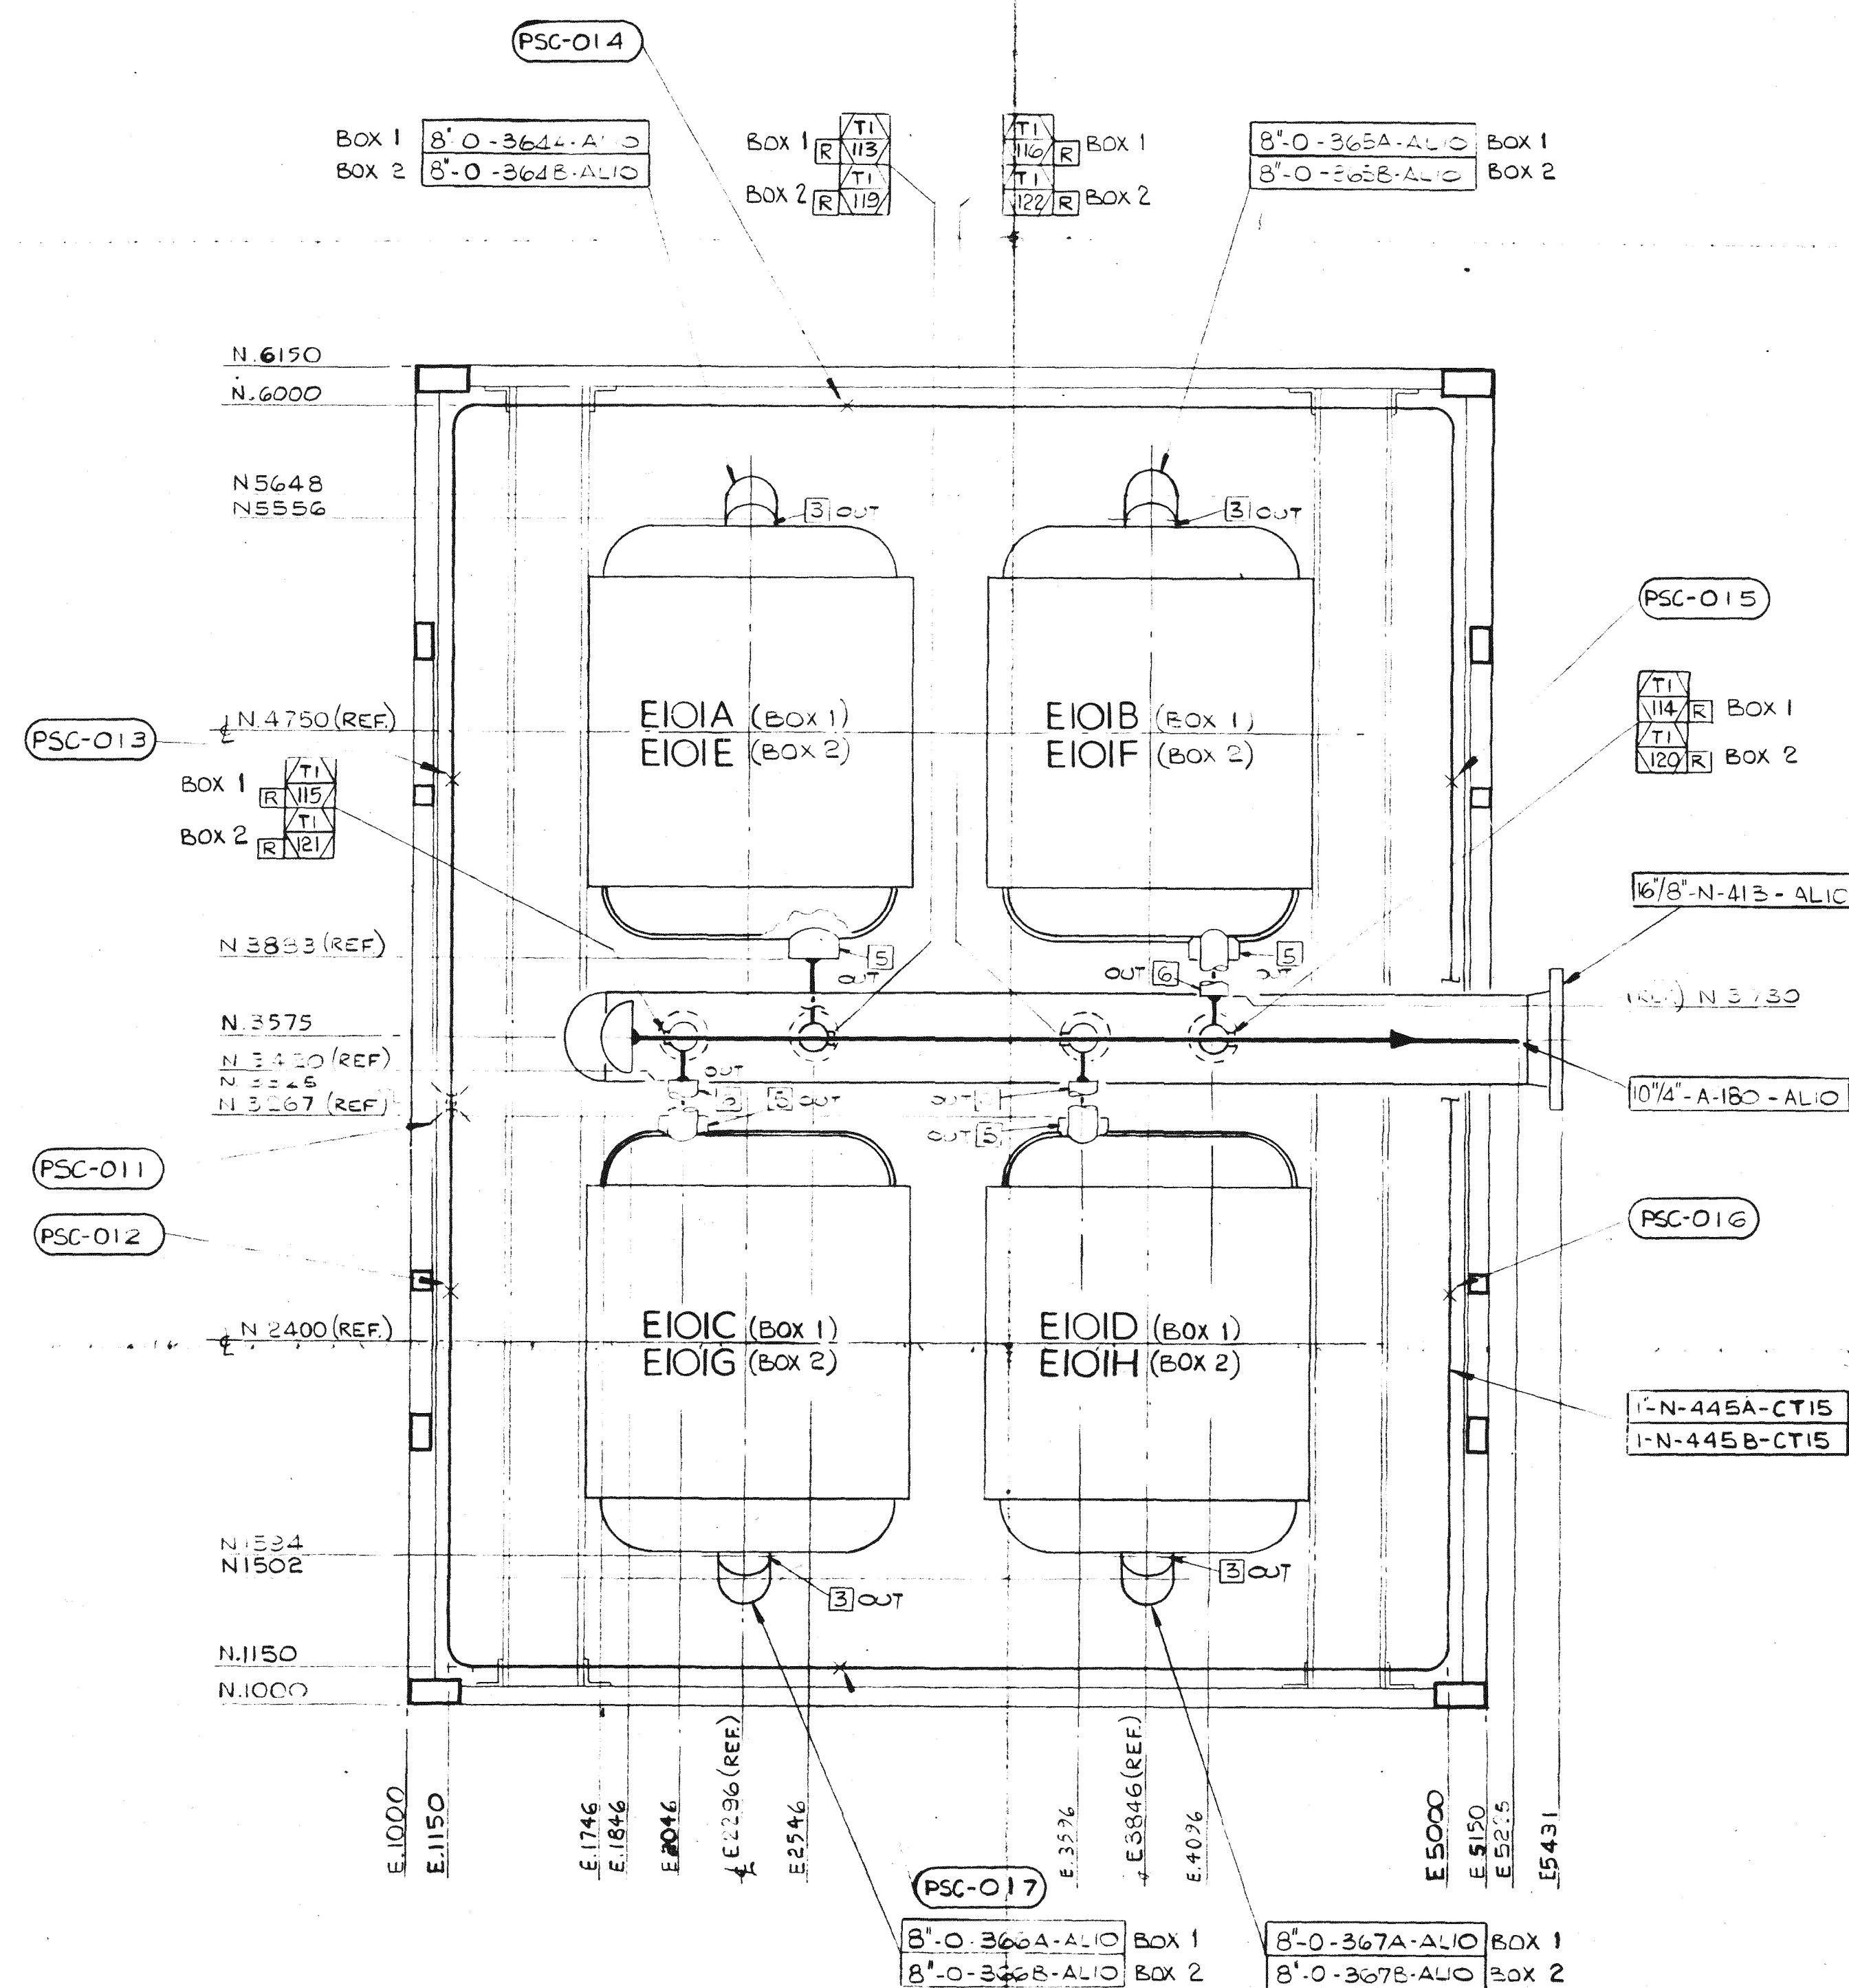

PLAN EL107700 TO EL103480

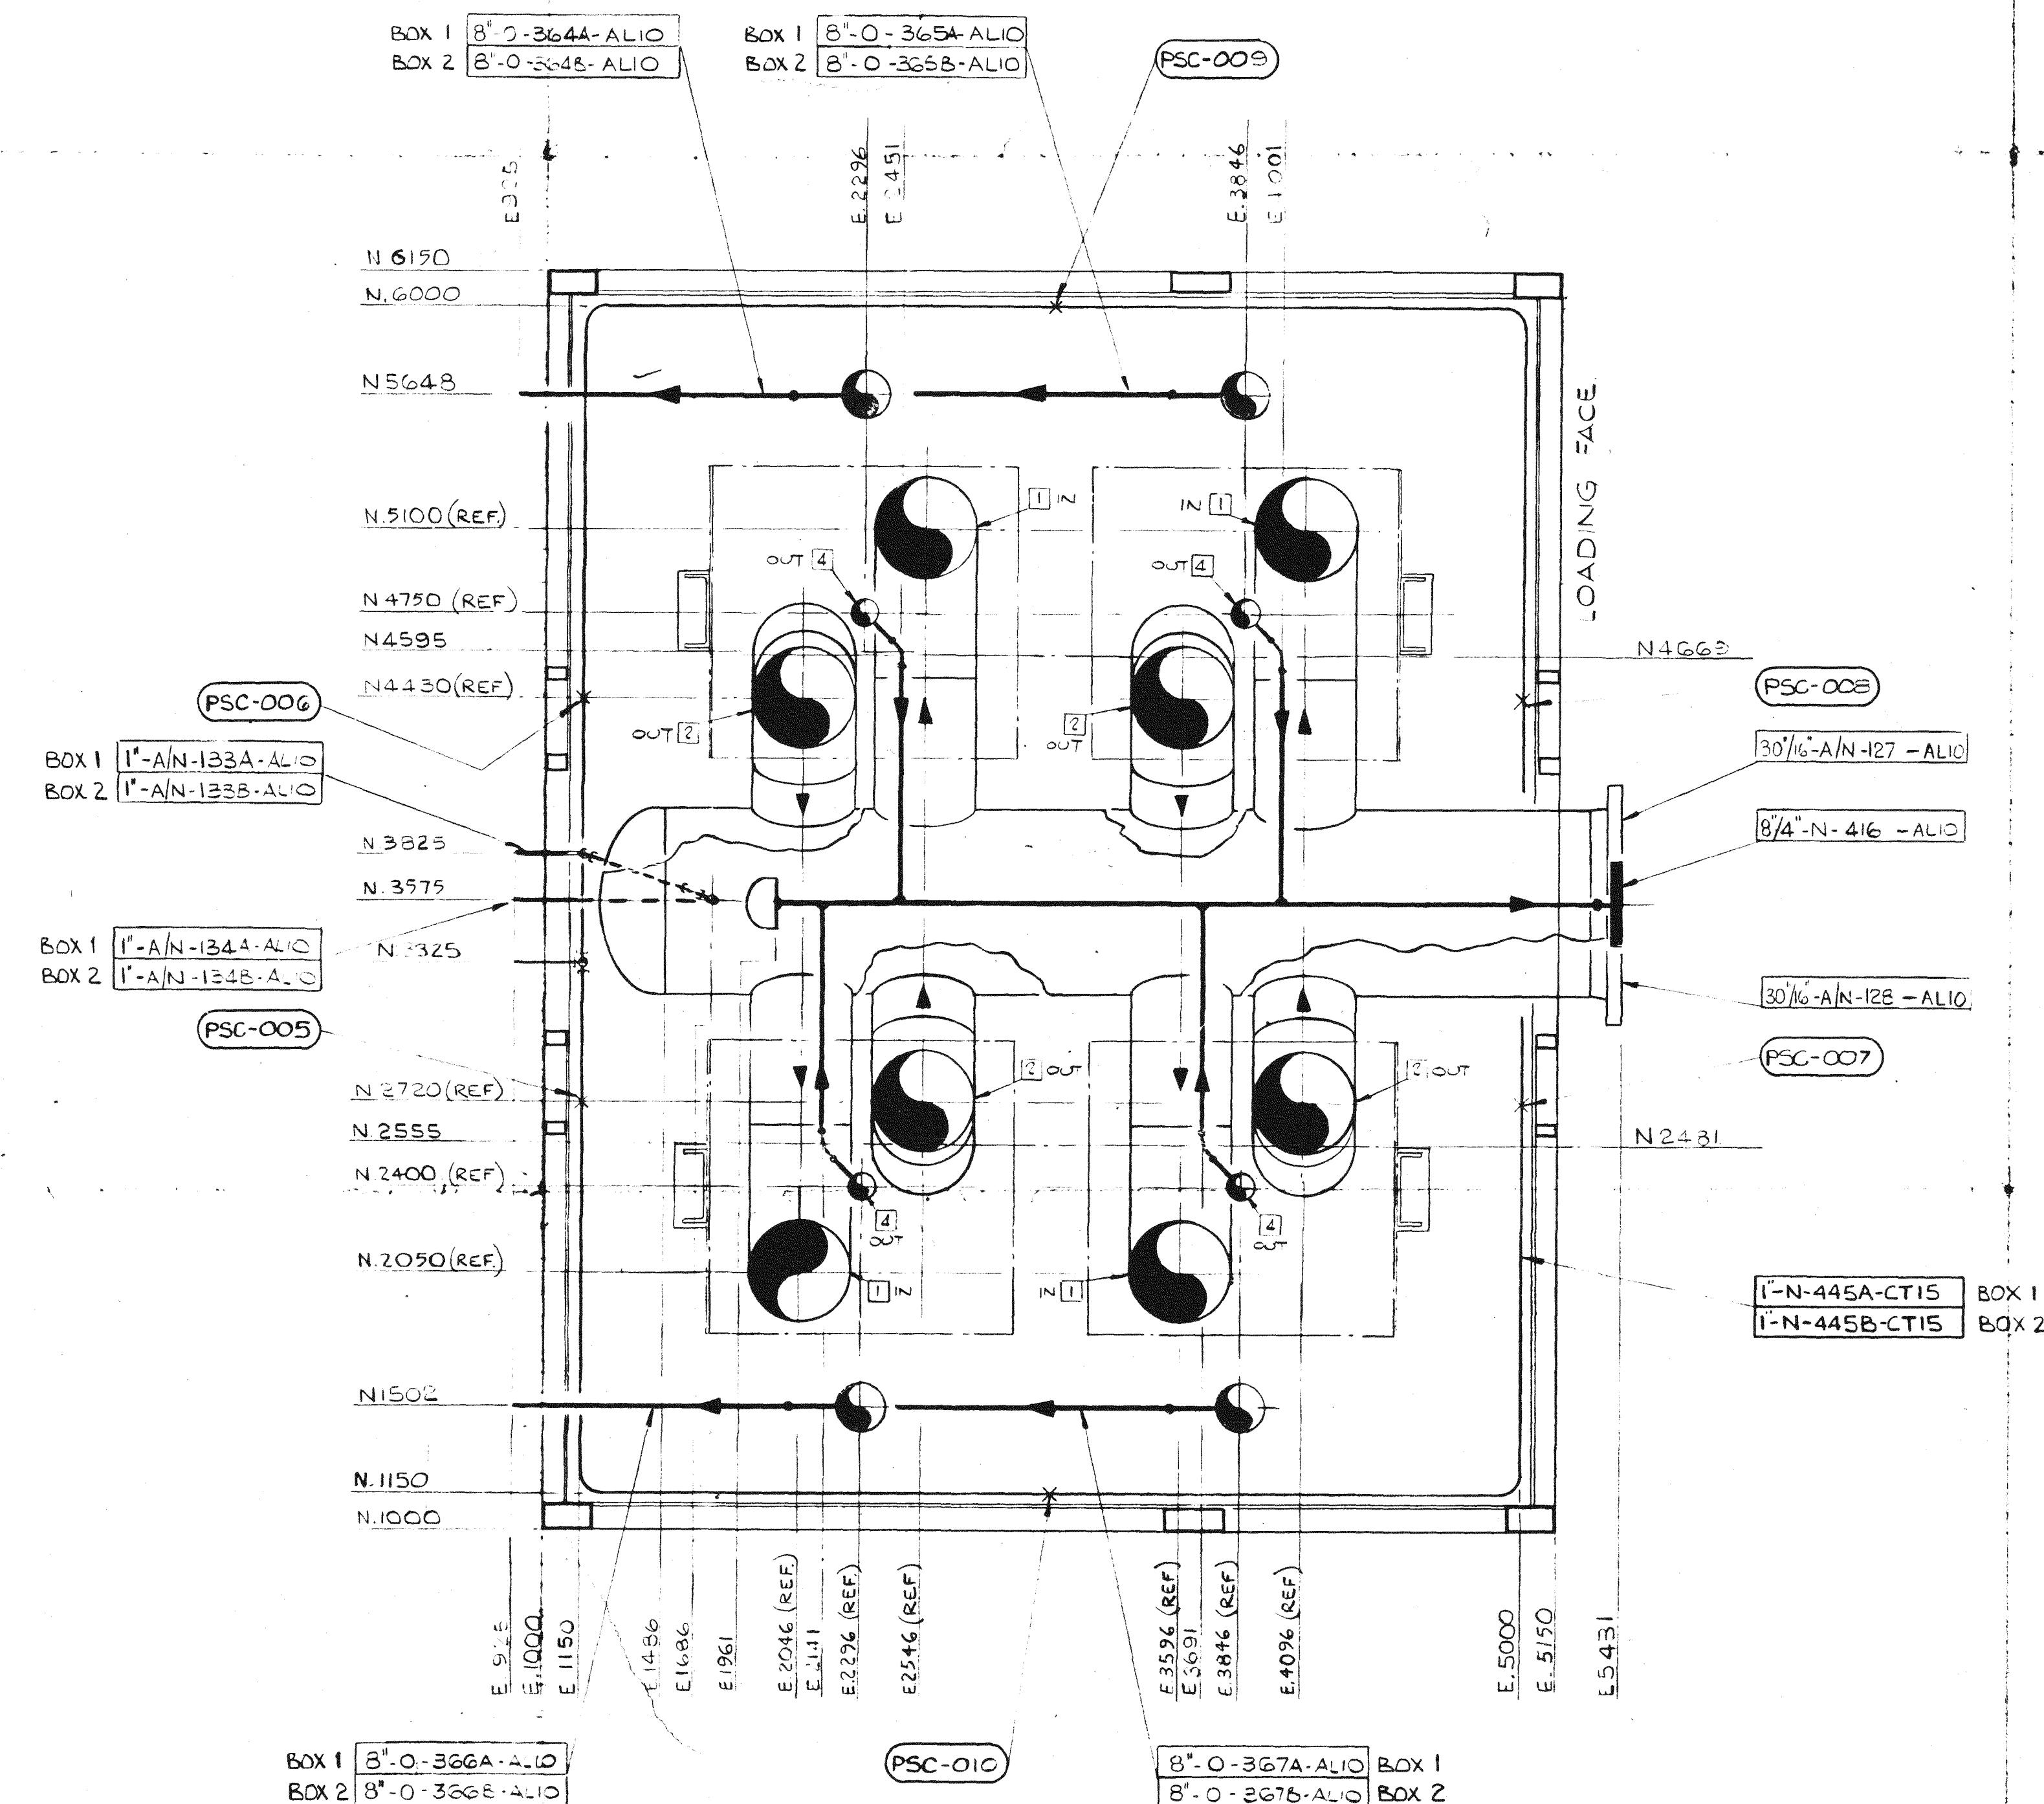

PLAN EL103480 TO EL100000

REFERENCE DRAWINGS	
DES. NO.	TITLE
8295-6010	HEAT EXCHANGER BOX PIPING ISOMETRIC
FOR ALL OTHER REFERENCE DRAWINGS SEE RELEVANT DRAWING REGISTER	
FOR GENERAL NOTES SEE DRAWING 8295-6001-INT-1	

- NOTES:
- 1) LINE 'A' TO BE SUFFIX 'A' IN BOX 1
 - 2) LINE 'B' TO BE SUFFIX 'B' IN BOX 2
 - 3) ELEVATIONS ON THIS DRAWING ARE TO APL'S DATUM 100.000 m WHICH IS EQUAL TO 100.500 m PLANT SITE ELEVATION (HUNTING SURVEY 5.25 m)

REV	DATE	DESCRIPTION	BY	CHK	APPROVED
01	02-04-86	AS BUILT CONDITION	BY	CHK	APPROVED

☐ (1) Work May Proceed, Review and Re-submit. Work May Proceed Subject to Incorporation of Changes Indicated.	DATE RECEIVED 7/20/82	DRAWN STATUS
☐ (2) Review and Re-submit. Work May Proceed. Review Not Required. Work May Proceed.	DATE 7/20/82	BECHTEL HOUSTON

V.P. - 1011-004-A-001-A-15
EQUIP. NO. E-6402-A-1

REV	ECN	REVISIONS	DATE	DRAWN	CHKD	APPD
0		ORIGINAL ISSUE	2-2-88	J.G.S.	T.G.V.	W.D.

HEAT EXCHANGER BOX PIPING PLANS



BECHTEL HOUSTON SAUDI YANBU PETROCHEMICAL COMPANY N/R 11211-84-A-1 DWG NO.	YANBU SAUDI ARABIA	DRAWN: J.G.S. DATE: 8-11-81 CHECKED: T.G.V. SCALE: 1:20 APPROVED: [Signature]	DRG NO. 8295-601A SHEET 2 OF 2
---	-----------------------	---	-----------------------------------




EL 112645

EL 112735

GOX INLET STR 3
EL 103475

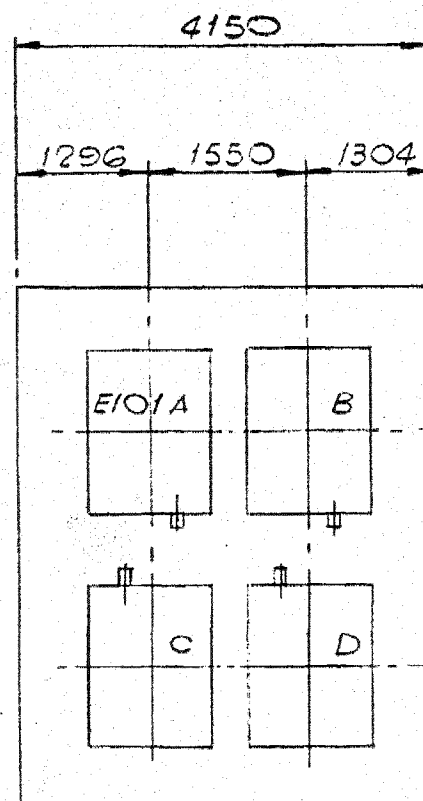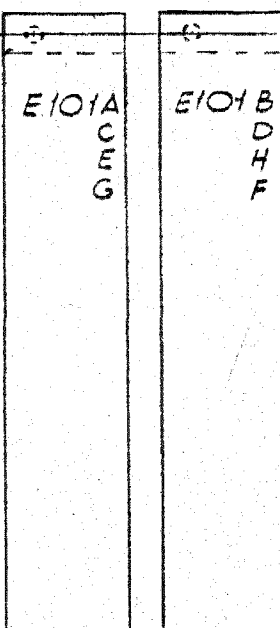

PLAN BOX 1

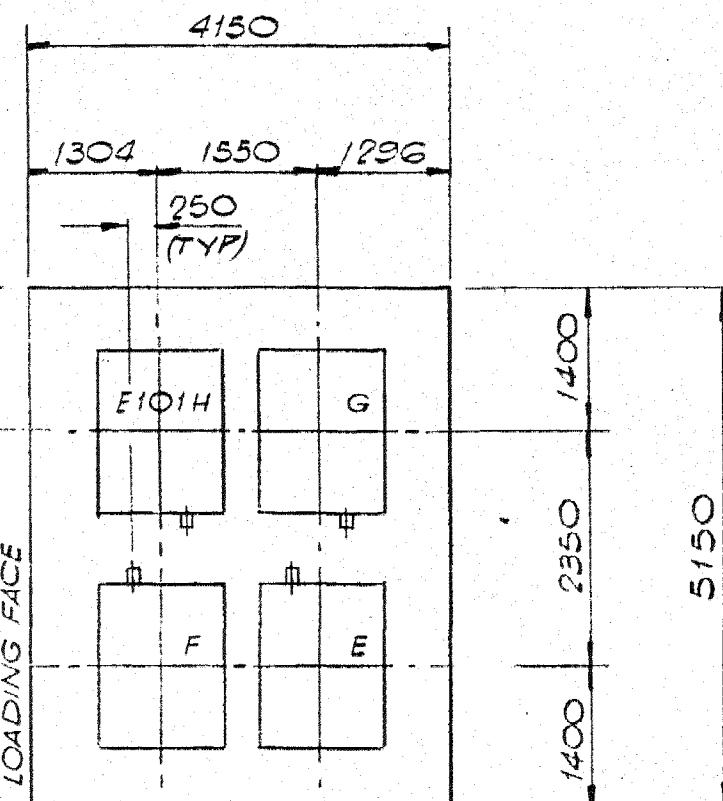

PLAN BOX 2

U.S. STL EL 100000

NOTES

1. APL DATUM ELEVATION 100.000 M = PLANT
SITE ELEVATION 100.500 M (HUNTING
SURVEY EL. 5.25M).

BECHTEL
HOUSTON

SAUDI YANBU

PETROCHEMICAL COMPANY

M/R 11211-64-A-1

DWG NO.

- ☒ (1) Work May Proceed.
☐ (2) Revise and Resubmit. Work May Proceed Subject to Incorporation of Changes Indicated.
☐ (3) Revise and Resubmit. Work May Not Proceed.
☐ (4) Review Not Required. Work May Proceed.

DATE RECEIVED 5/11/82

IMPORTANT: Permission to proceed does not constitute acceptance or approval of design details, calculations, analyses, test methods or materials developed or selected by the supplier and does not relieve supplier from full compliance with contractual obligations.

DWG. STATUS
SIGNED *H. P. King*
DATE 5/10/82
BECHTEL
HOUSTON

HO-80808 (9/76)

V.P. 11211-064-A-001AC

EQUIP. NO. E-6402 A-H

SCALE: -

DRAWN: T.G.V.

CHECKED: *John*

APPROVED:

DATED 4-2-82

AIR PRODUCTS LTD.

HEAT EXCHANGER BOX

EQUIPMENT ARRANGEMENT


DRAWING No. 8295-600D

SHEET 1 OF 1

REVISIONS

No.	DESCRIPTION	DATE	BY	CHK.
O	ORIGINAL ISSUE	4-2-82	TGV	<i>John</i>
P	PRELIMINARY ISSUE	23-10-81	TGV	

9.9

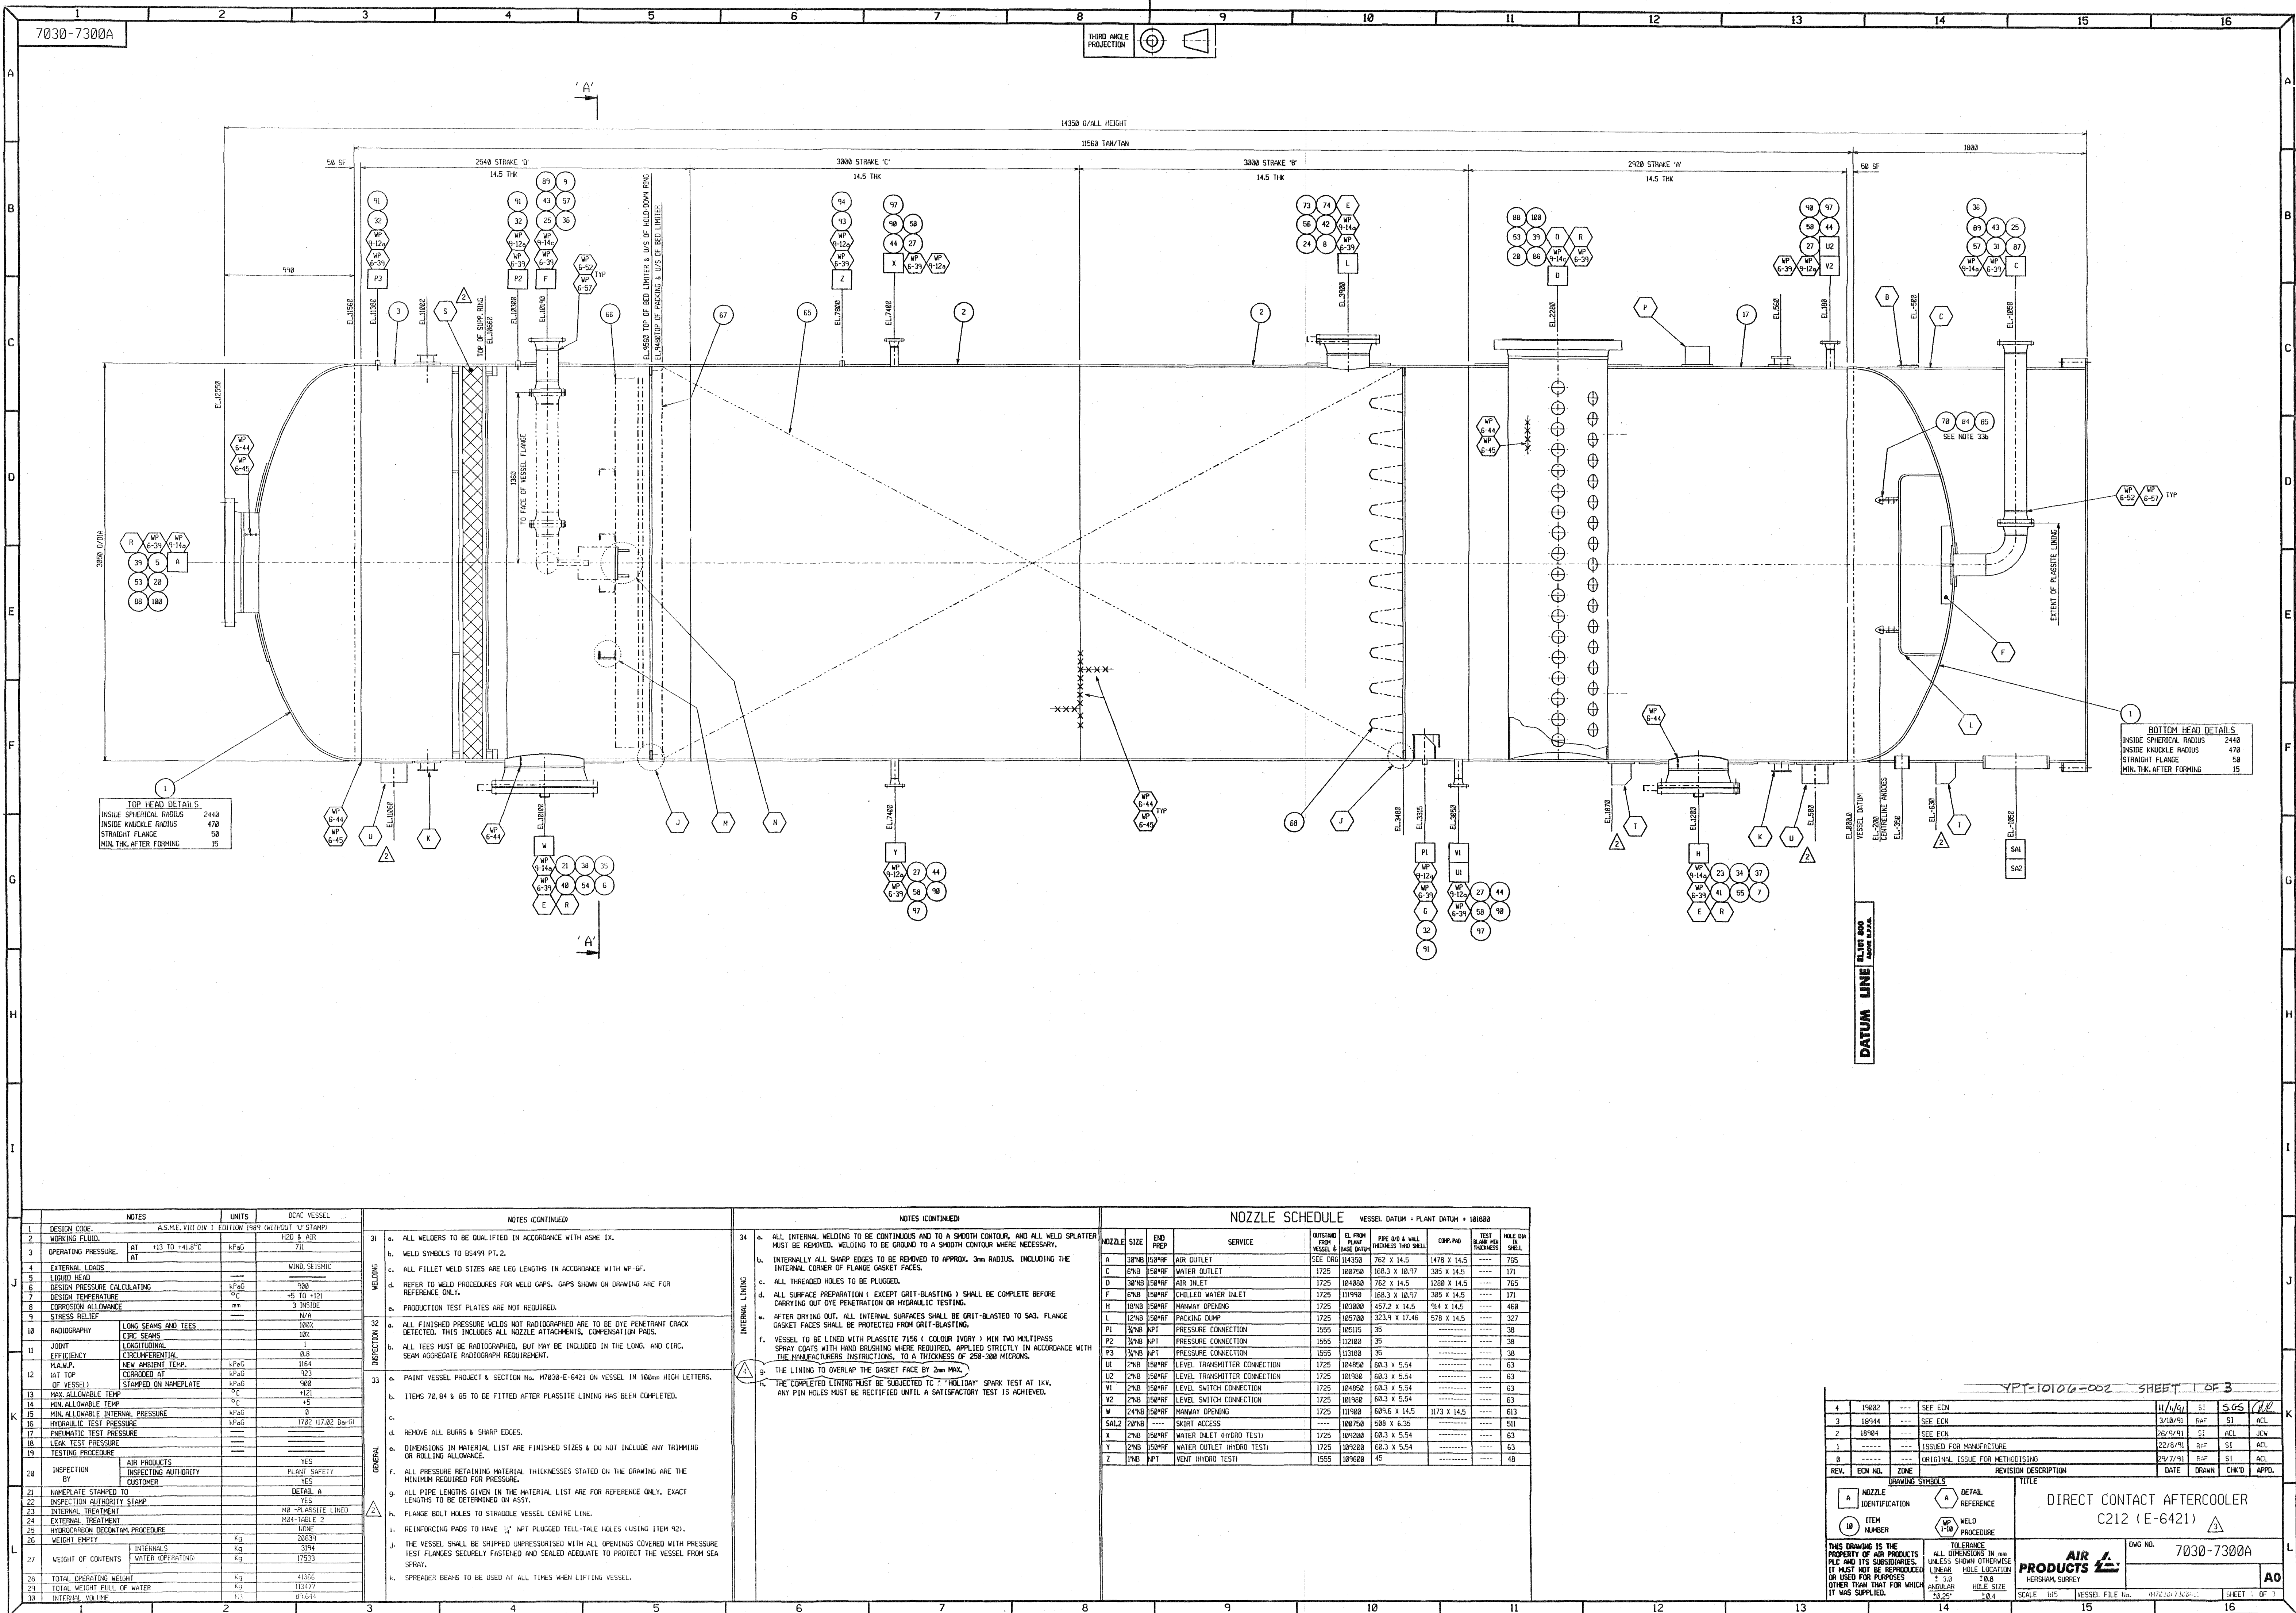

NOTES		UNITS	DCAC VESSEL
1	DESIGN CODE	ASME VIII DIV 1 EDITION 1989 (WITHOUT 'U' STAMP)	H2O & AIR
2	WORKING FLUID	AT	7.1
3	OPERATING PRESSURE	AT	13 TO 14.8°C
4	EXTERNAL LOADS	---	WIND, SEISMIC
5	LIQUID HEAD	---	900
6	DESIGN PRESSURE CALCULATING	MPaG	900
7	DESIGN TEMPERATURE	°C	+5 TO +121
8	CORROSION ALLOWANCE	mm	3 INSIDE
9	STRESS RELIEF	---	N/A
10	RADIOGRAPHY	LONG SEAMS AND TEES	100%
11	JOINT	CIRC. SEAMS	100%
12	MAWP	NEW AMBIENT TEMP.	1164
13	HT TOP	CORRODED AT	900
14	MAX. ALLOWABLE TEMP.	°C	+121
15	MIN. ALLOWABLE INTERNAL PRESSURE	MPaG	0
16	HYDRAULIC TEST PRESSURE	MPaG	1702 (17.02 Bar-G)
17	PNEUMATIC TEST PRESSURE	---	---
18	LEAK TEST PRESSURE	---	---
19	TESTING PROCEDURE	---	---
20	INSPECTION BY	AIR PRODUCTS	YES
21	INSPECTION AUTHORITY	INSPECTING AUTHORITY	PLANT SAFETY
22	NAMEPLATE STAMPED TO	---	DETAIL A
23	INSPECTION AUTHORITY STAMP	---	163
24	INTERNAL TREATMENT	---	HP-PLASSITE LINED
25	EXTERNAL TREATMENT	---	MS-4-TABLE 2
26	HYDROCARBON DECONTAM. PROCEDURE	---	---
27	WEIGHT EMPTY	INTERNAL	394
28	WEIGHT OF CONTENTS	WATER OPERATING	17533
29	TOTAL OPERATING WEIGHT	---	41366
30	TOTAL WEIGHT FULL OF WATER	---	183477
31	INTERNAL VOLUME	---	95644

NOTES (CONTINUED)	
31	a. ALL WELDERS TO BE QUALIFIED IN ACCORDANCE WITH ASME IX.
32	b. WELD SYMBOLS TO BE QUALIFIED IN ACCORDANCE WITH ASME IX.
33	c. ALL FILLET WELD SIZES ARE LEG LENGTHS IN ACCORDANCE WITH WP-6F.
34	d. REFER TO WELD PROCEDURES FOR WELD GAPS. GAPS SHOWN ON DRAWING ARE FOR REFERENCE ONLY.
35	e. PRODUCTION TEST PLATES ARE NOT REQUIRED.
36	f. ALL FINISHED PRESSURE WELDS NOT RADIOGRAPHED ARE TO BE DYE PENETRANT CRACK DETECTED. THIS INCLUDES ALL NOZZLE ATTACHMENTS, CONNECTIONS, PADS.
37	g. ALL TEES MUST BE RADIOGRAPHED, BUT MAY BE INCLUDED IN THE LONG AND CIRC. SEAM AGGREGATE RADIOGRAPH REQUIREMENT.
38	h. PAINT VESSEL PROJECT & SECTION NO. 17030-E-6421 ON VESSEL IN 100mm HIGH LETTERS.
39	i. ITEMS 70.64 & 85 TO BE FITTED AFTER PLASSITE LINING HAS BEEN COMPLETED.
40	j. REMOVE ALL BURRS & SHARP EDGES.
41	k. DIMENSIONS IN MATERIAL LIST ARE FINISHED SIZES & DO NOT INCLUDE ANY TRIMMING OR ROLLING ALLOWANCE.
42	l. ALL PRESSURE RETAINING MATERIAL THICKNESSES STATED ON THE DRAWING ARE THE MINIMUM REQUIRED FOR PRESSURE.
43	m. ALL PIPE LENGTHS GIVEN IN THE MATERIAL LIST ARE FOR REFERENCE ONLY. EXACT LENGTHS TO BE DETERMINED ON ASST.
44	n. FLANGE BOLT HOLES TO STAGGER VESSEL CENTRE LINE.
45	o. REINFORCING PADS TO HAVE 1/2" NPT PLUGGED TELL-TALE HOLES (USING ITEM 90).
46	p. THE VESSEL SHALL BE SHIPPED UNPRESSURIZED WITH ALL OPENINGS COVERED WITH PRESSURE TEST PLUGS SECURELY FASTENED AND SEALED ADEQUATE TO PROTECT THE VESSEL FROM SEA SPRAY.
47	q. SPREADER BEAMS TO BE USED AT ALL TIMES WHEN LIFTING VESSEL.

NOTES (CONTINUED)	
48	a. ALL INTERNAL WELDING TO BE CONTINUOUS AND TO A SMOOTH CONTOUR, AND ALL WELD SPATTER MUST BE REMOVED. WELDING TO BE GRIND TO A SMOOTH CONTOUR WHERE NECESSARY.
49	b. INTERNALLY ALL SHARP EDGES TO BE REMOVED TO APPROX. 3mm RADIUS, INCLUDING THE INTERNAL CORNER OF FLANGE GASKET FACES.
50	c. ALL THREADED HOLES TO BE PLUGGED.
51	d. ALL SURFACE PREPARATION (EXCEPT GRIT-BLASTING) SHALL BE COMPLETE BEFORE CARRYING OUT DYE PENETRANT OR HYDRAULIC TESTING.
52	e. AFTER DRYING OUT, ALL INTERNAL SURFACES SHALL BE GRIT-BLASTED TO SA3. FLANGE GASKET FACES SHALL BE PROTECTED FROM GRIT-BLASTING.
53	f. VESSEL TO BE LINED WITH PLASSITE 7156 (COLOUR IVORY) 1 MIN TWO MULTIPASS SPRAY COATS WITH HAND BRUSHING WHERE REQUIRED, APPLIED STRICTLY IN ACCORDANCE WITH THE MANUFACTURER'S INSTRUCTIONS, TO A THICKNESS OF 200-300 MICRONS.
54	g. THE LINING TO OVERLAP THE GASKET FACE BY 2mm MAX.
55	h. THE COMPLETED LINING MUST BE SUBJECTED TO "HOLIDAY" SPARK TEST AT 1KV. ANY PIN HOLES MUST BE RECTIFIED UNTIL A SATISFACTORY TEST IS ACHIEVED.

NOZZLE SCHEDULE		VESSEL DATUM = PLANT DATUM = 181000	
NOZZLE	END PREP	SERVICE	WITNESS FROM VESSEL & PLANT
A	30°NB 150°MF	AIR OUTLET	1725 100750 168.3 X 14.5 1478 X 14.5 765
B	6°NB 150°MF	WATER OUTLET	1725 100750 168.3 X 10.97 305 X 14.5 171
C	30°NB 150°MF	AIR INLET	1725 100750 168.3 X 14.5 1280 X 14.5 765
D	6°NB 150°MF	CHILLED WATER INLET	1725 111990 168.3 X 10.97 305 X 14.5 171
E	18°NB 150°MF	MANWAY OPENING	1725 103000 457.2 X 14.5 914 X 14.5 460
F	12°NB 150°MF	PACKING DUMP	1725 105700 323.8 X 17.46 578 X 14.5 327
G	3/4"NB NPT	PRESSURE CONNECTION	1555 10515 35 38
H	3/4"NB NPT	PRESSURE CONNECTION	1555 112100 35 38
I	3/4"NB NPT	PRESSURE CONNECTION	1555 113100 35 38
J	2"NB 150°MF	LEVEL TRANSMITTER CONNECTION	1725 104850 60.3 X 5.54 63
K	2"NB 150°MF	LEVEL TRANSMITTER CONNECTION	1725 104900 60.3 X 5.54 63
L	2"NB 150°MF	LEVEL SWITCH CONNECTION	1725 104950 60.3 X 5.54 63
M	2"NB 150°MF	LEVEL SWITCH CONNECTION	1725 105000 60.3 X 5.54 63
N	24"NB 150°MF	MANWAY OPENING	1725 111900 689.6 X 14.5 1173 X 14.5 613
O	24"NB 150°MF	SKIRT ACCESS	1725 100750 588 X 6.35 511
P	2"NB 150°MF	WATER INLET (HYDRO TEST)	1725 109200 60.3 X 5.54 63
Q	2"NB 150°MF	WATER OUTLET (HYDRO TEST)	1725 109200 60.3 X 5.54 63
R	1"NB NPT	VENT (HYDRO TEST)	1555 109200 45 48

YPT-10106-002 SHEET 1 OF 3											
4	19002	---	SEE ECH	11/1/91	S1	SGS	ACL				
3	18944	---	SEE ECH	3/18/91	RP	S1	ACL				
2	18904	---	SEE ECH	26/9/91	S1	ACL	NEW				
1	-----	---	ISSUED FOR MANUFACTURE	22/8/91	RP	S1	ACL				
0	-----	---	ORIGINAL ISSUE FOR METHODISING	29/7/91	RP	S1	ACL				
REV.	ECH NO.	ZONE	REVISION DESCRIPTION	DATE	DRAWN	CHK'D	APP'D.				
DRAWING SYMBOLS				TITLE							
A NOZZLE IDENTIFICATION		A DETAIL REFERENCE		DIRECT CONTACT AFTERCOOLER							
18 ITEM NUMBER		MP WELD TUB PROCEDURE		C212 (E-6421) 							
THIS DRAWING IS THE PROPERTY OF AIR PRODUCTS PLC AND ITS SUBSIDIARIES. IT MUST NOT BE REPRODUCED OR USED FOR PURPOSES OTHER THAN THAT FOR WHICH IT WAS SUPPLIED.				TOLERANCE ALL DIMENSIONS IN mm UNLESS SHOWN OTHERWISE LINEAR POS. LOCATION + 2.0 - 0.8 ANGULAR 10/50 HOLE SIZE + 0.4 - 0.4				DWG NO. 7030-7300A			
				AIR PRODUCTS 		HERSWAM, SURREY		A0			
				SCALE 1:105		VESSEL FILE NO. 8972.10.7.3.02-1		SHEET 1 OF 3			
12				13				14			
15				16				17			

DESCRIPTION	KEY	SIZE(IN)	OUTSTAND FROM £	ELEVATION	FACING	OVERALL THICKNESS	O/D	DRILLING
COOLING WATER INLET	A	6	1850	10600	FF	34mm	11"	8No HOLES ø7/8" ON 9-1/2" PCD
WASTE GAS INLET	B	30	1850	2807	FF	35mm	38-3/4"	28No HOLES ø1-3/8" ON 36" PCD
CHILLED WATER OUTLET	C	6	1850	316	FF	34mm	11"	8No HOLES ø7/8" ON 9-1/2" PCD
OVERFLOW OUTLET	D	6	1850	166	FF	34mm	11"	8No HOLES ø7/8" ON 9-1/2" PCD
MANWAY	H1	20	1850	1920	FF	32mm		
MANWAY	H2	20	1850	10582	FF	32mm		
LEVEL TRANS CONNS	J1	2	1850	2128	FF	19mm	6"	4No HOLES ø3/4" ON 4-3/4" PCD
LEVEL TRANS CONNS	J2	2	1850	906	FF	19mm	6"	4No HOLES ø3/4" ON 4-3/4" PCD
LEVEL GAUGE CONNS	U1	1-1/2	1850	2276	FF	17mm	5"	4No HOLES ø5/8" ON 3-7/8" PCD
LEVEL GAUGE CONNS	U2	1-1/2	1850	176	FF	17mm	5"	4No HOLES ø5/8" ON 3-7/8" PCD
LEVEL SWITCH CONNS	V1	2	1850	1316	FF	19mm	6"	4No HOLES ø3/4" ON 4-3/4" PCD
LEVEL SWITCH CONNS	V2	2	1855	166	FF	19mm	6"	4No HOLES ø3/4" ON 4-3/4" PCD
TANK DRAIN	E	1-1/2 NPT	1750	75	THREADED WITH PLUG			

DESIGN : DESIGN CODE BS4994 1987 CATEGORY 2
DESIGN PRESSURE 0.35 BAR G + 1500 mmWG.
WIND LOAD ANSI A58.1 (95 Km/HR)
DESIGN TEMPERATURE +6°C ~20°C
EARTHQUAKE LOADING UBC 1982 ED. (ZONE 1)


SHELL GRP (SCOTT BADER 397 PA MAIN STRUCTURAL RESIN WITH GEL COAT EXTERIOR FINISH)
DISTRIBUTION UPVC/GRP/STAINLESS STEEL
PACKING PVC (DF121)
PACK SUPPORT GRP
BED LIMITER GRP/POLYPROPYLENE
BIRD SCREEN GRP
NOZZLES PVC/GRP
DRIFT ELIMINATOR PVC - BRENTWOOD CD-20
ALL GASKETS 6mm THICK NEOPRENE (60-70 SHORE HARDNESS)
EXTERNAL BOLTS CERAMISED MILD STEEL
INTERNAL BOLTS STAINLESS STEEL

40-078/4 - DETAIL OF CONICAL & DISTRIBUTION SECTION
40-078/5 - DETAIL OF PACKING SECTION
40-078/6 - DETAIL OF BASE SECTION


10% EXTRA OF ALL EXTERNAL BOLTS REQUIRED

FOUNDATION SURFACE UNDER TOWER TO BE STEEL FLOAT FINISHED SMOOTH.
BEFORE ERECTING TOWER, FOUNDATION SURFACE TO BE SWEEPED CLEAN OF
ANY LOOSE STONES, etc.
TOWER TO STAND ON 2 LAYERS OF BITUMASTIC FELT 3mm THICK LAID OVER
AREA OF BASE OF TOWER (FELT SUPPLIED BY DeCo.)

SHIPPING WEIGHT 7050 Kg.
OPERATING WEIGHT 23230 Kg.

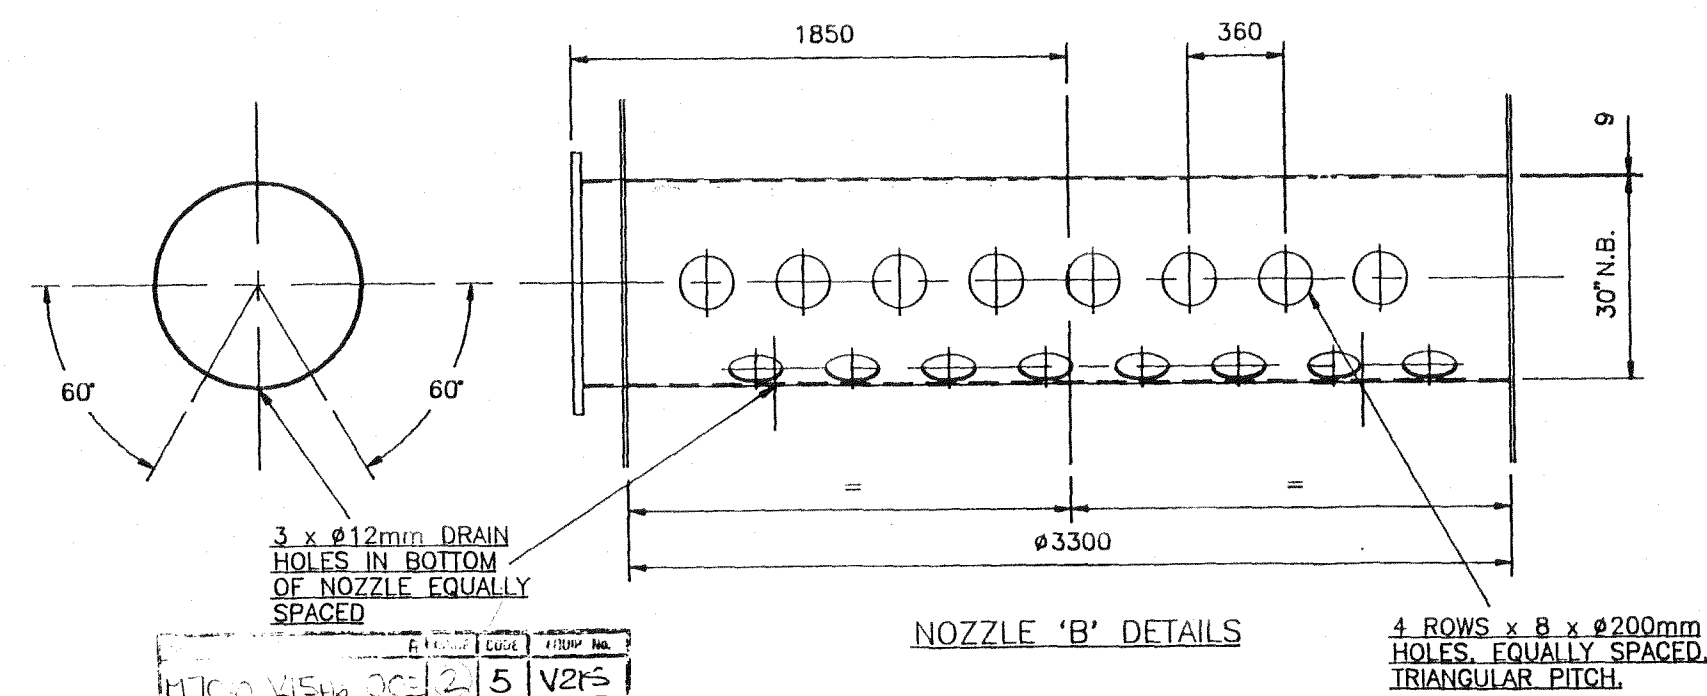

TITLE				G.A.WASTE CHILLER TOWER-SAUDI ARABIA (NOMINALLY 3300 I/D 12073 HIGH)	
CUSTOMER				AIR PRODUCTS (UK) LTD	
DRAWN BY		SWT	SCALE	1:20	DATE 02/07/91
APPROVED BY		<i>[Signature]</i>	DRG. No 40-078/1		
			REV A		


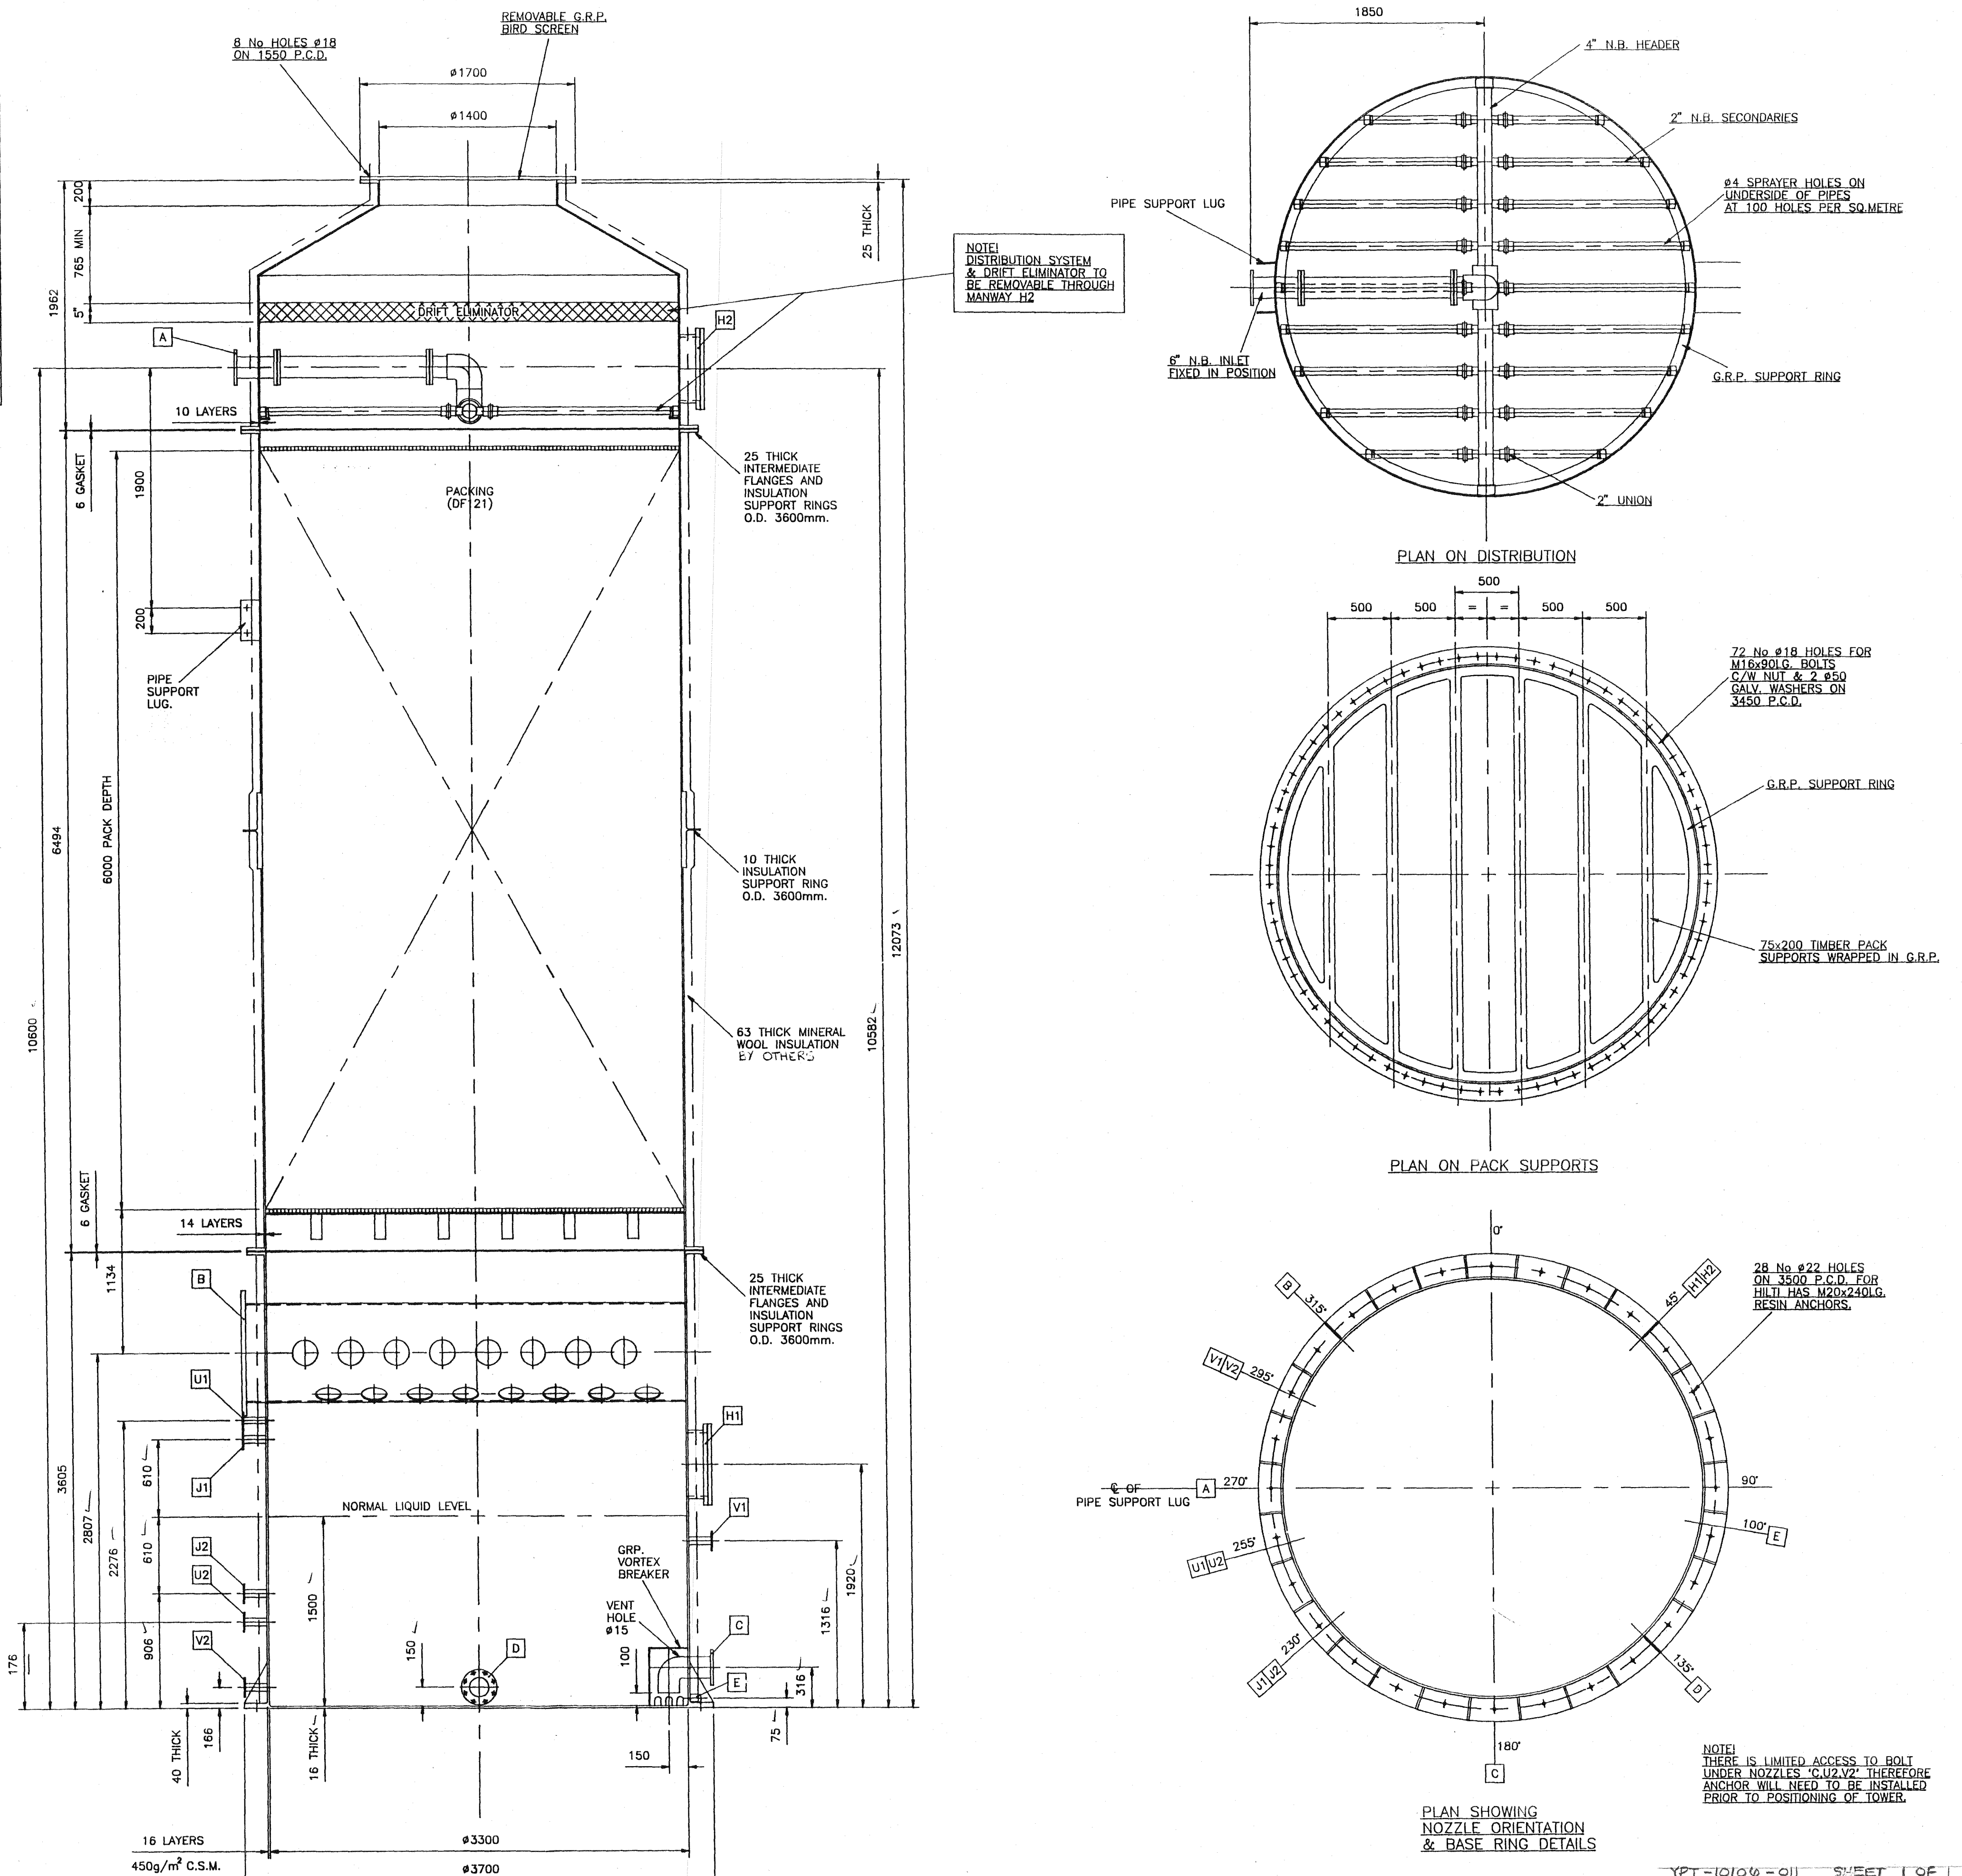


NOTE!
THERE IS LIMITED ACCESS TO BOLT
UNDER NOZZLES 'C.U2.V2' THEREFORE
ANCHOR WILL NEED TO BE INSTALLED
PRIOR TO POSITIONING OF TOWER.


THIS DRAWING IS THE PROPERTY OF
DAVENPORT ENGINEERING CO. LTD., AND MUST
NOT BE USED FOR ANY PURPOSE DETRIMENTAL
TO THE INTERESTS OF THAT COMPANY. ITS
CONTENTS ARE NOT TO BE COPIED OR
DISCLOSED TO ANY THIRD PARTY EITHER
WHOLLY OR IN PART WITHOUT THE CONSENT
OF DAVENPORT ENGINEERING CO. LTD.

V-215
(E-6422)

BOLTS INDICATED BY AN ARROW ARE PROVIDED WITH BEARING BOXES AND ARE TO BE USED FOR OPENING AND CLOSING THE UNIT.

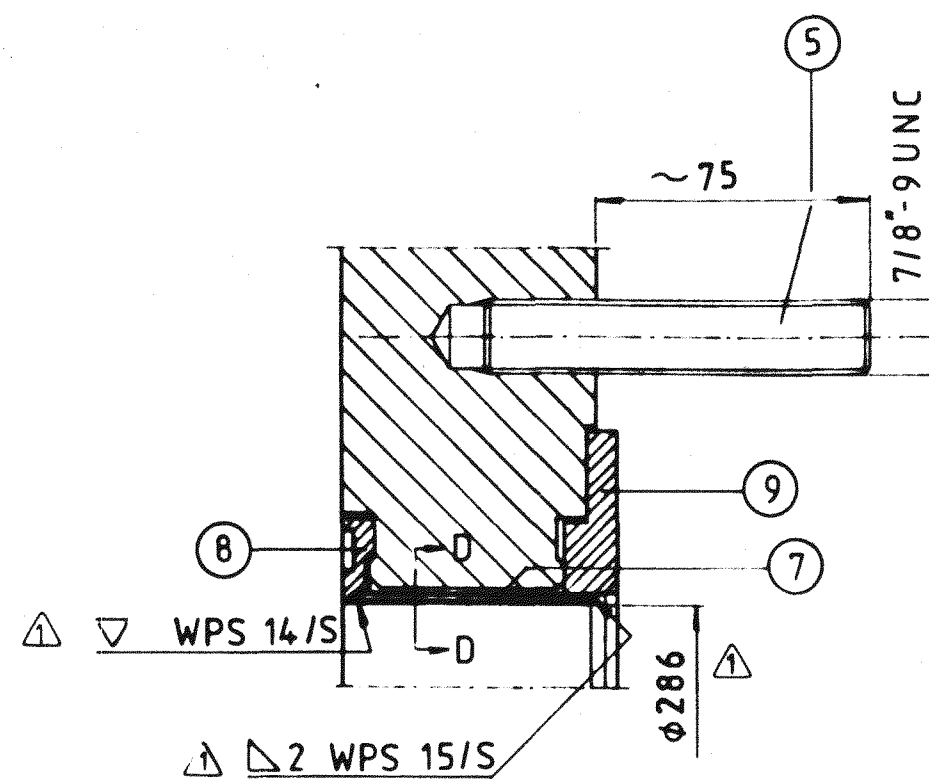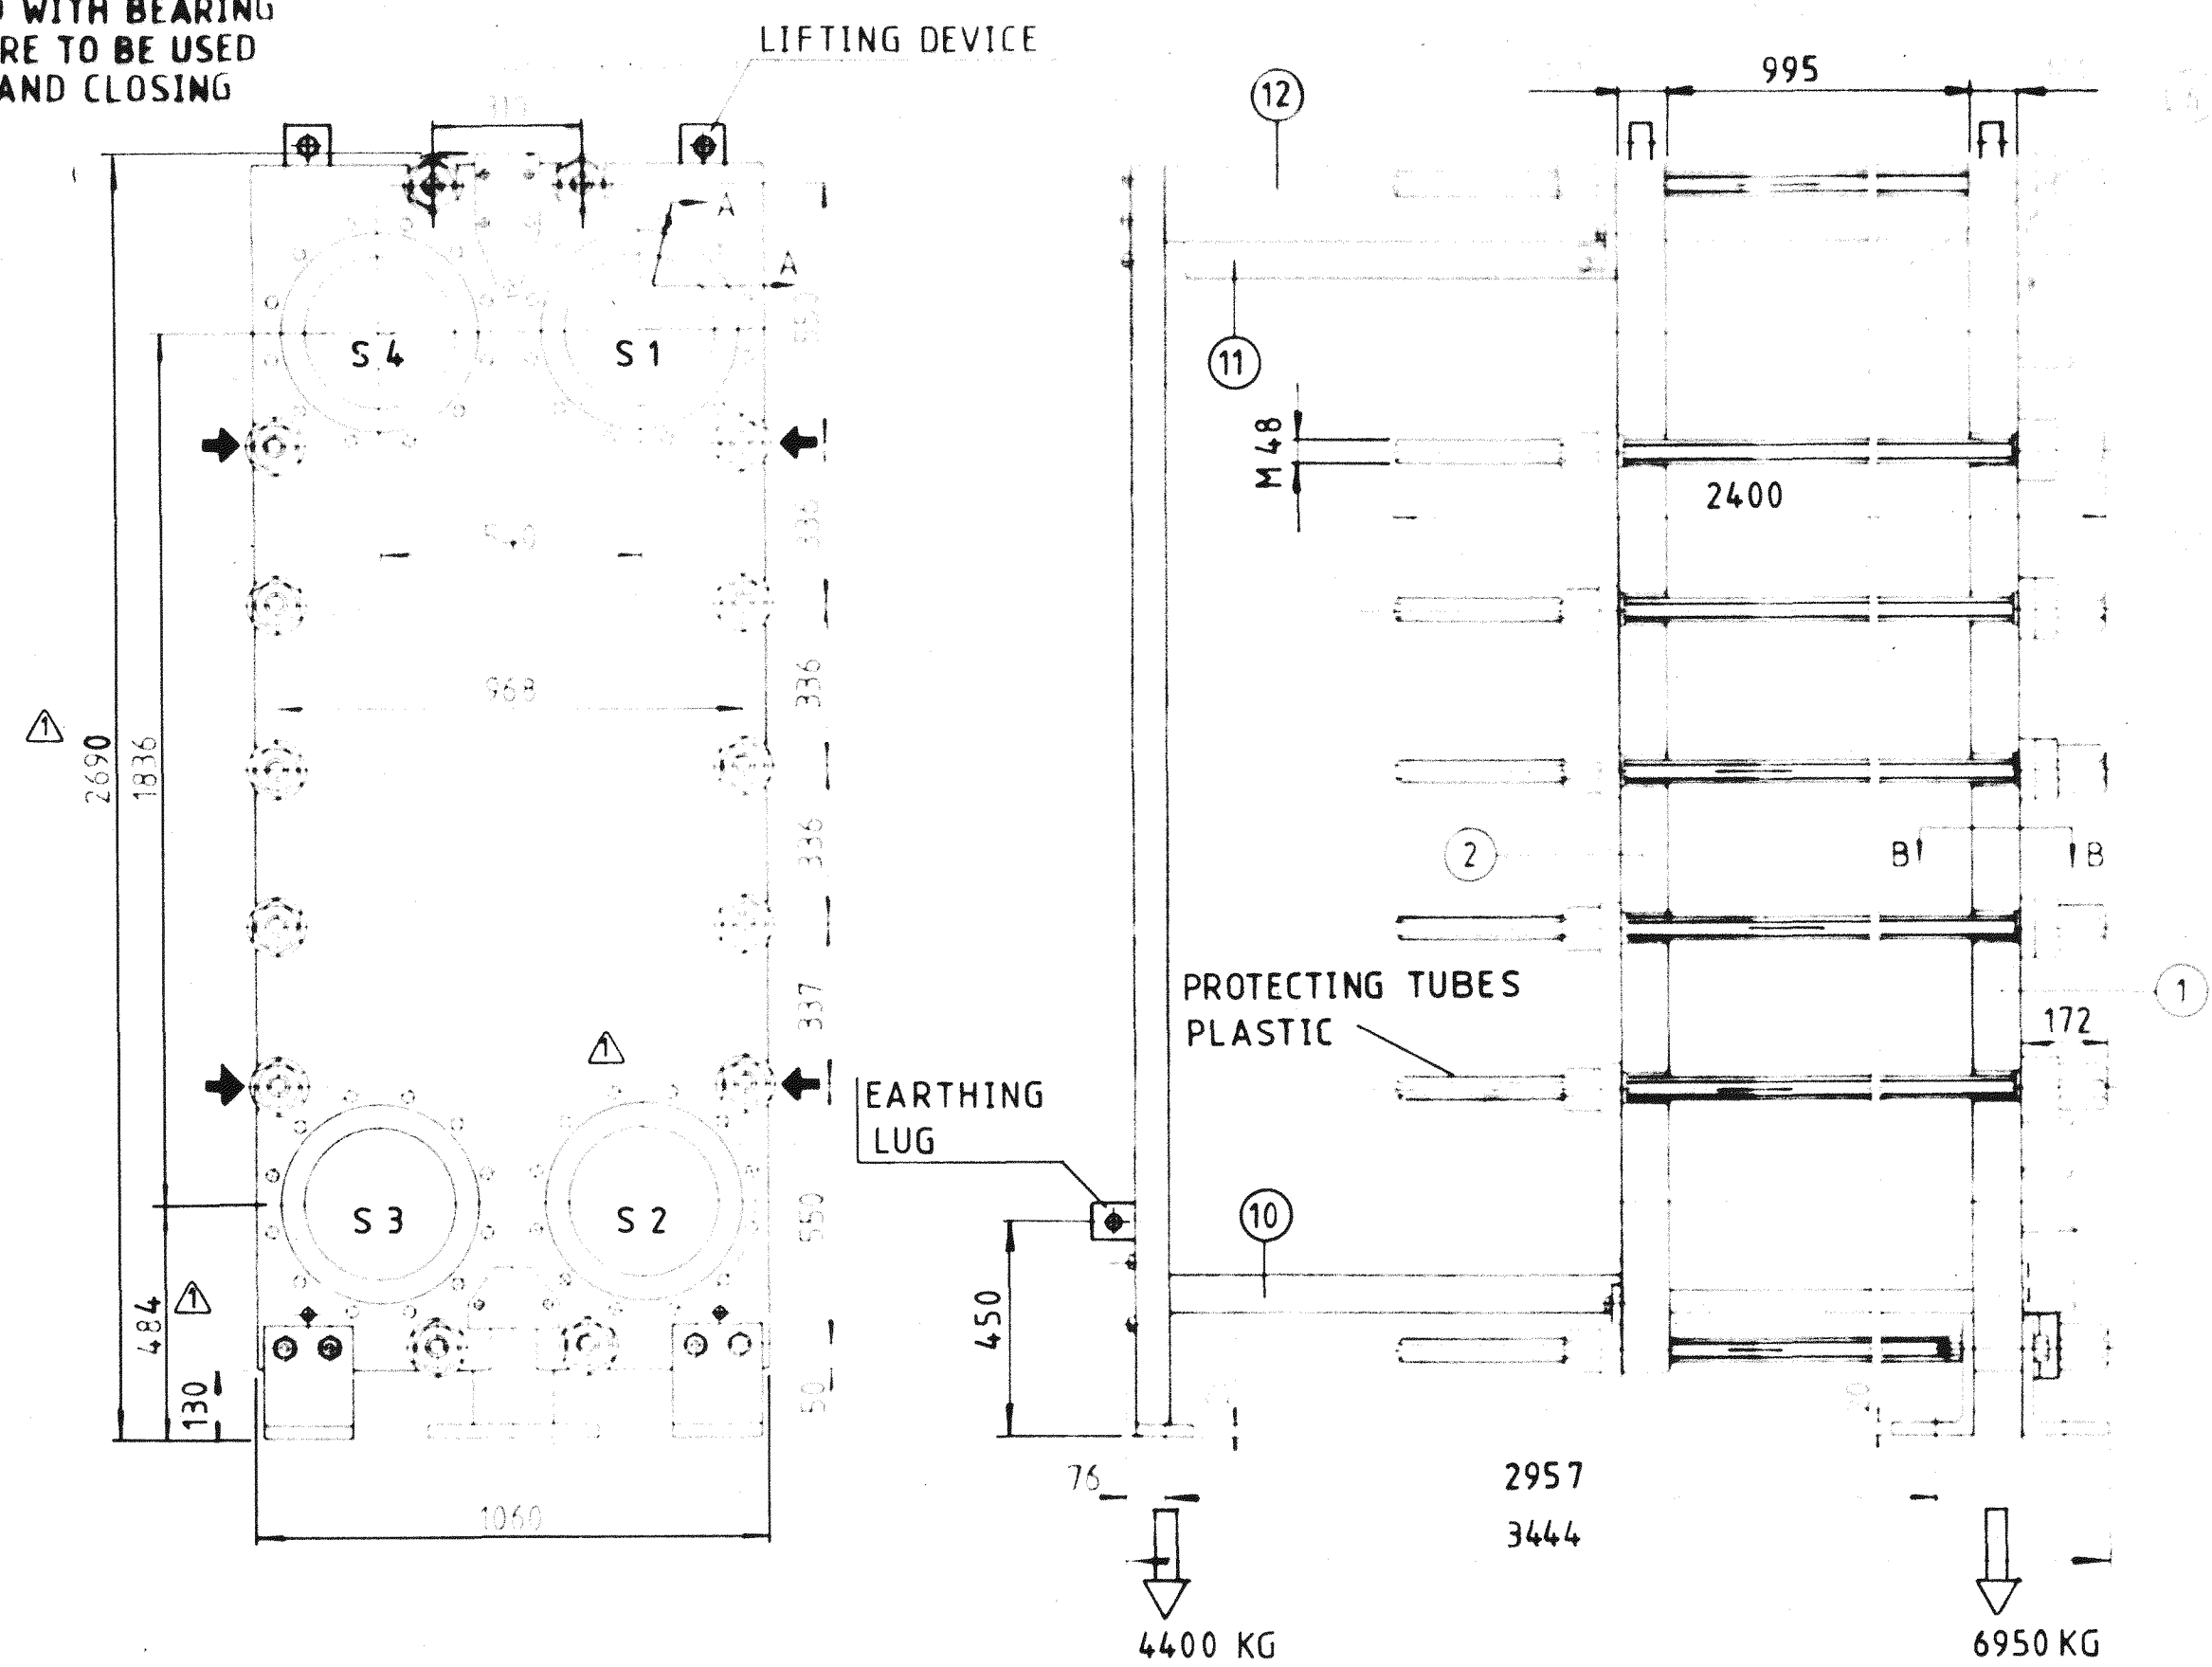






S1, S2, S3, S4

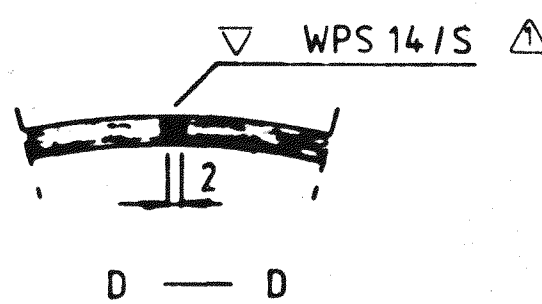

THE PLATE HEAT EXCHANGER MEETS THE REQUIREMENTS ACCORDING TO UNIT-FORM BUILDING CODE ZONE 1 AND SPEC. A-10




ALLOWABLE NOZZLE LOADS (ON EACH NOZZLE):

F_x 3000 N
F_y 7000 N
F_z 20000 N
M_x 10300 Nm
M_y 4000 Nm
M_z 6000 Nm

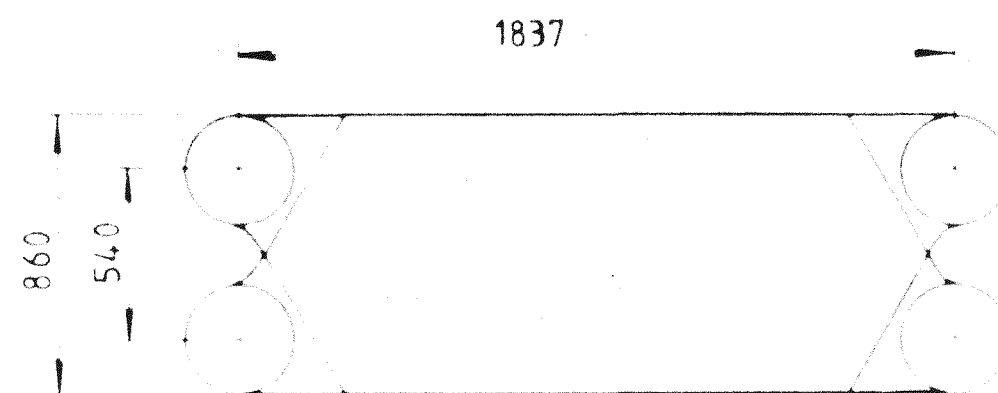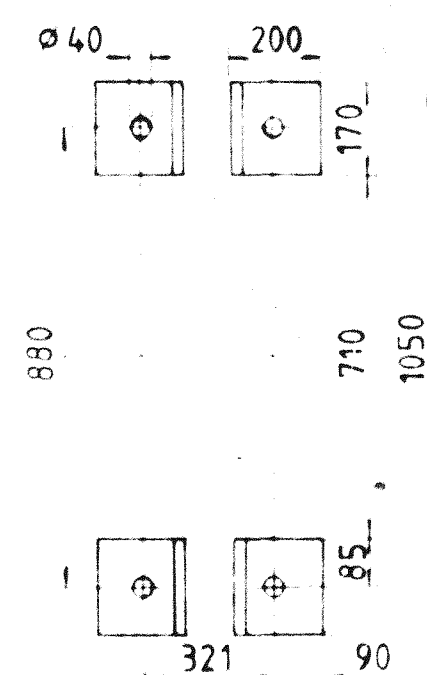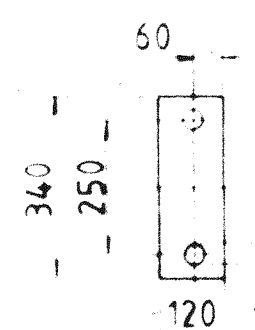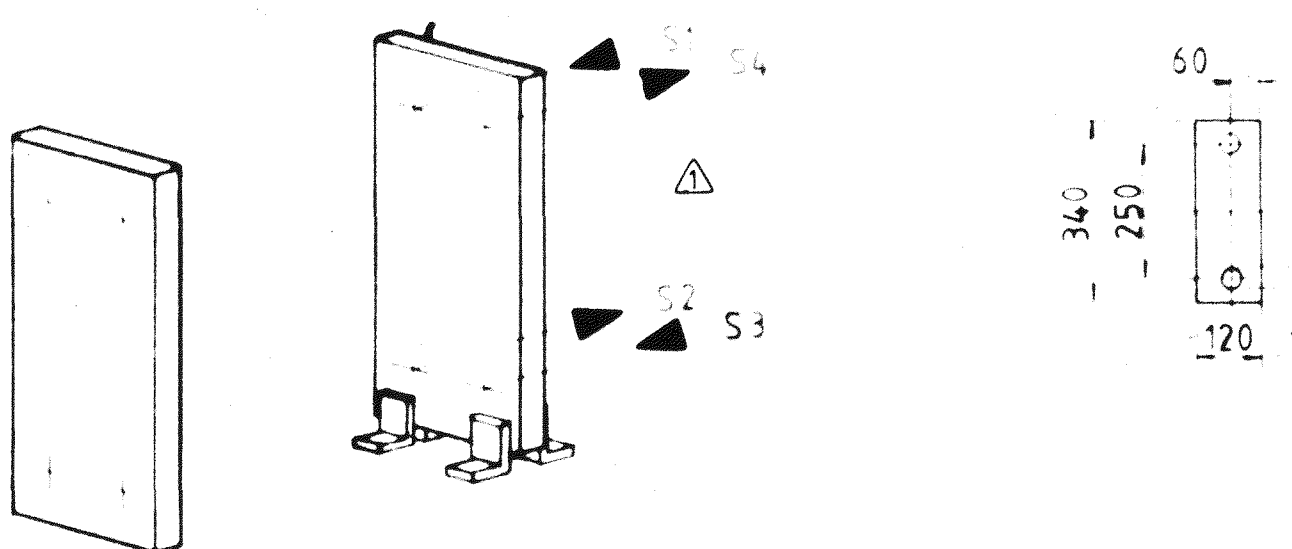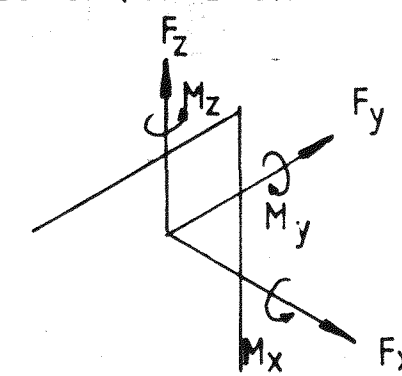

PRESSURE LOAD AREA 17620 cm²
LENGTH OF GASKET 10370 mm

AIR, THE FRAME PARTS ARE NOT IN CONTACT WITH THE FLOWING LIQUIDS

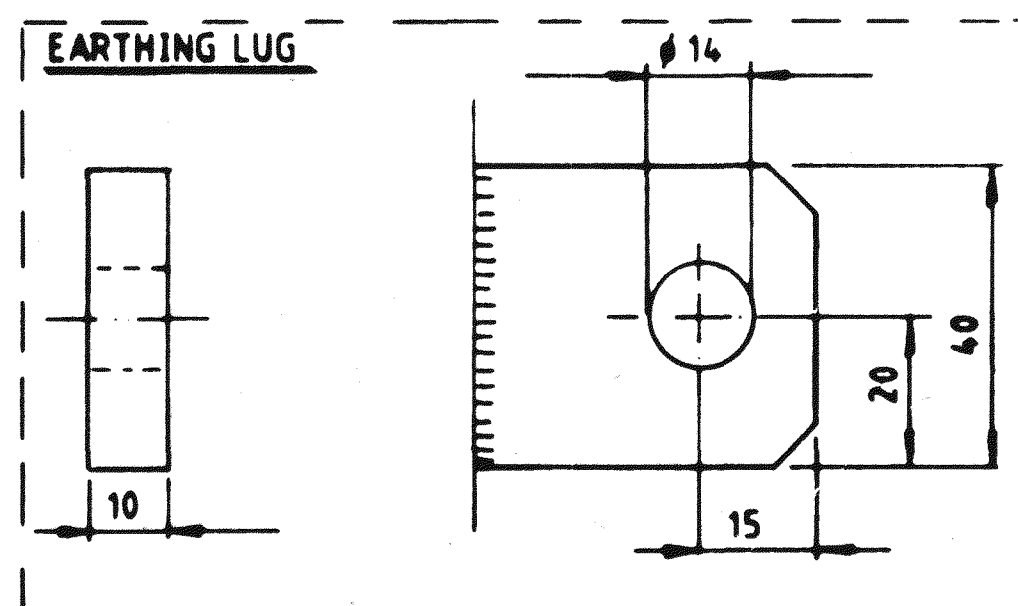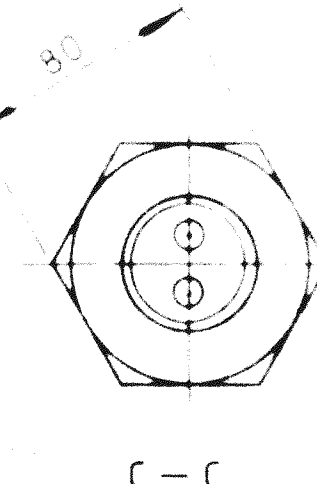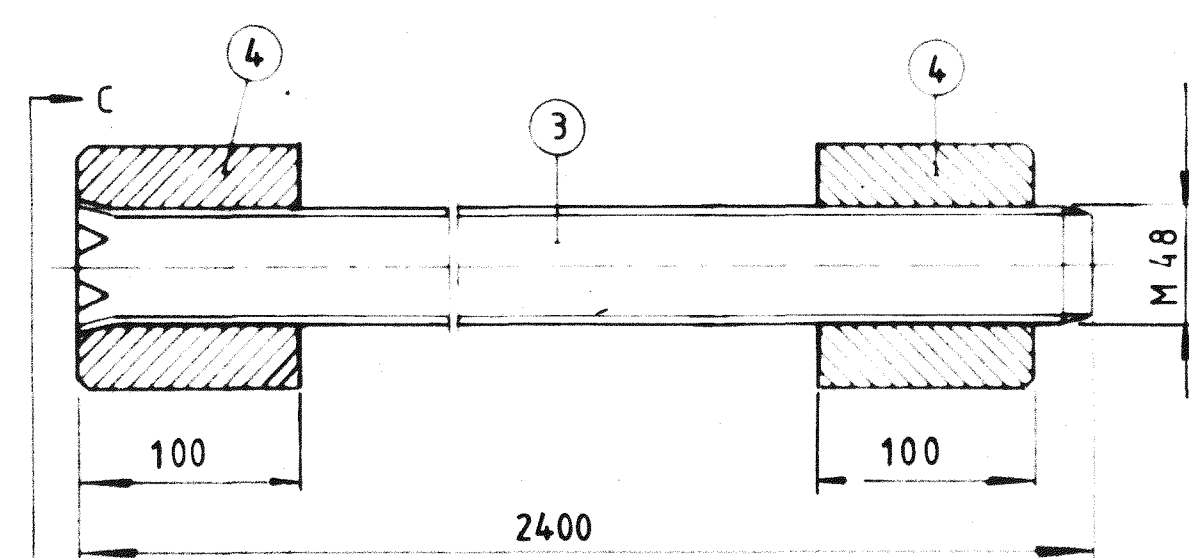

ALFA-LAVAL

TYPE AX30-HA
MAX. WORK. PRESSURE (GAUGE) 1500 KPa / 15 bar
MANUF. NO. 30100-13040
MAX. WORK. TEMPERATURE 150 °C / 302 °F
YEAR 1982 VOLUME 1400
ITEM NO. E-7405
PO. NO. 11211-074-E-40 C

THIS HEAT EXCHANGER IS MANUFACTURED BY ALFA-LAVAL AB

DESIGN SPECIFICATIONS: DS-E-7405, A-10, A11, W-1, X-1
DESIGN CODE ASME VIII, DIV. I
DESIGN PRESSURE 1500 KPA (GAUGE)
DESIGN TEMP 150 °C
INITIAL AND ROUTINE HYDROSTATIC TEST PRESSURE: 2250 KPA
MIN. TEMP. OF WATER FOR HYDROSTATIC TEST: 16 °C
CORROSION ALLOWANCE 0 mm
CONNECTION: SEAM WELD X-RAY, OTHER WELDS LIQUID PENETRANT EXAMINATION
HEAT TREATMENT NONE
WEIGHT EMPTY / FILLED WITH WATER 7300 / 8700 kg
OPERATING WEIGHT: 8700 kg
TOTAL LIQUID VOLUME 1400 L
214 PLATES 0.8 mm AISI 316
GASKET NITRILE

CARRYING BAR ALUMINUM 311 PLATE 1446 MM PLATE PACK
GUIDING BOLT CALCULATED 257 PLATE 1195 MM PLATE PACK

PAINTING SPECIFICATION ACC. TO X-1 DRWG. 000-EX-001

SIDE		PRIMARY	SECONDARY			
△	MEDIUM	FRESH WATER	FRESH COOLING WATER			
	FLOWRATE	96,1 KG/S	132,8 KG/S			
△	TEMP. INLET/OUTLET	46 - 35°C	33,3 - 42 °C			
	PRESSURE DROP	35 KPA	62 KPA			
△	CONNECTION INLET/OUTLET	S3 - S4	S1 - S2			
	CONNECTIONS MATERIAL	SA 182 - F 316 L / SA 240 - 316 L				
△	CONNECTION SIZE	12" ANSI B 16.5 150 ^{lb} RF				
△	12	1	CARRYING BAR SUPPORT	SIS 1412-00	eq to ASTM A 283 Grade C e D	
△	11	1	CARRYING BAR PROFILE	SIS 2332-02	AISI 304	
△	10	1	GUIDING BAR LINED WITH STAINLESS STEEL	SIS 1412-00 SIS 2332-02	eq.to ASTM A 283 Gr. C e D AISI 304	
	9	4	FLANGE	SA 182-F316 L	-	CMTR
	8	4	GASKET RING	SA 182-F316 L	-	CMTR
	7	4	TUBE	SA 240-316 L	-	CMTR
	6	214	PLATES	SA 240-316	-	CMTR
	5	48	STUDBOLT	SA 193- B7	-	CMTR
	4	28	NUT	SB 150 - 630	-	CMTR
	3	14	TIGHTENING BOLT	AFNOR Z6 CNUD 15.04	-	CMTR
	2	1	PRESSURE PLATE	SA 516 - 60	-	CMTR
	1	1	FRAME PLATE	SA 516 - 60	-	CMTR
△	ITEM	QTY	DENOMINATION	GRADE	STANDARD	CERT

ITEM	QTY	DENOMINATION	GRADE	STANDARD	CERT
------	-----	--------------	-------	----------	------

APPROVED: [Signature]
Alfa-Laval AB
Lund, Sweden
CERTIFIED FINAL
Date: 2009-03-27
Sign: [Signature]
DATE RECEIVED: [Signature]
IMPORTANT: Permission to proceed does not constitute acceptance or approval of design details, calculations, analyses, test methods or materials developed or selected by the supplier and does not relieve supplier from full compliance with contractual obligations.
DWG. STATUS: SIGNED [Signature] DATE [Signature]
BECHTEL PETROLEUM, INC.

ALFA-LAVAL	ORDER NO. T 121907 (TO NO. 319071)
ALFA-LAVAL REPRESENTATIVE	PLATAGE SPECIFICATION NO. 30100-13040 ED. 2 MANUFACTURING NO. 30100-13040
MAIN CONTRACTOR	BECHTEL HOUSTON JOB NO. 11211 ITEM NO. E-7405 PO. NO. 11211-074-E-40 C-LAC
CUSTOMER	SAUDI YANBU PETROCHEMICAL COMPANY

AX 30-HA DESIGN AND ARRANGEMENT DRAWING		ALFA-LAVAL LUND SWEDEN
Scale: TSC	Dept: 800622	Drawn: 32297-0423

1 - 04-E-40

TANK PROCESS DATA SHEET


SHEET 1 OF 2

Client Bechtel

Plant 700 MT/D A.S.U.

Project No. M8295

NOTE: TANK CONNECTIONS & TANK SUPPLIED PIPE WILL BE PER THIS DWG. PLEASE ADD FACING & RATING DATA FOR THESE CONNECTIONS.

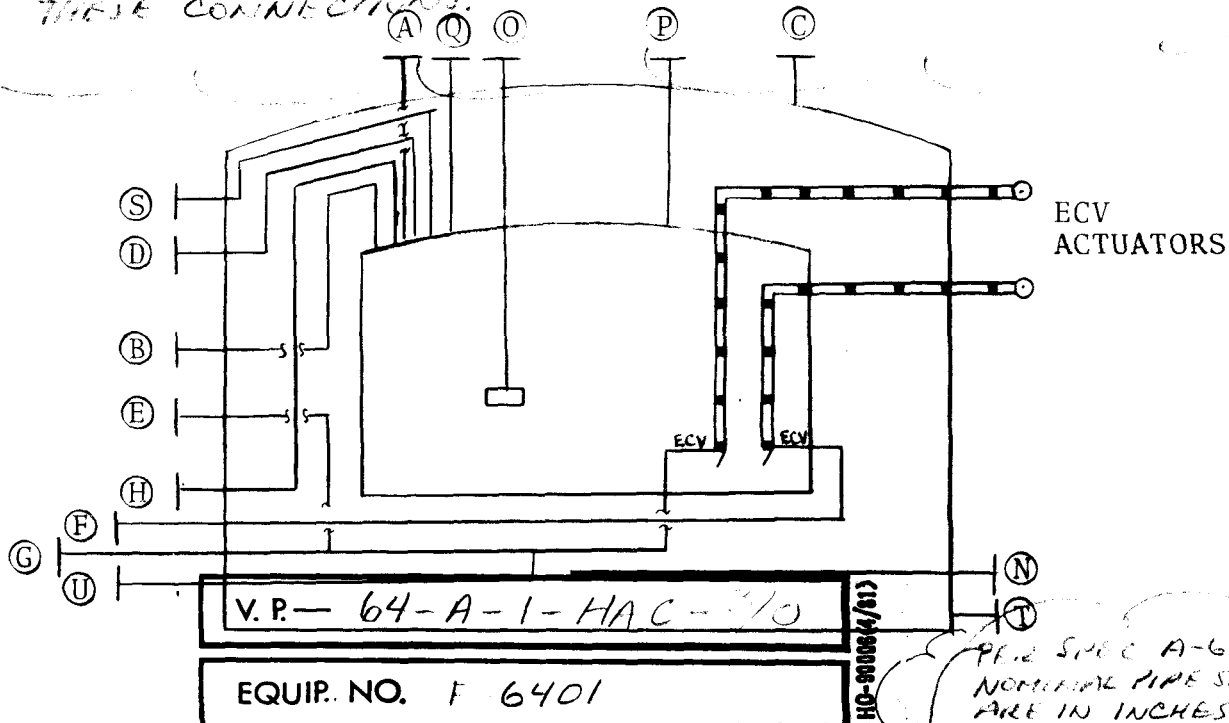

	PRESSURE		TEMPERATURE		NOZZLES	Tag	SIZE	No. ON	RATING	FACING
		Units		Units						
NORM. OP	101.3	kPa(A)	-183	°C	PRESSURE RELIEF CONN.	A	200	ONE		
					VENT/PRESSURISING CONN.	B	100	ONE		
					OUTER SHELL PSV CONN.	C		ONE		
DESIGN	13.8	kPa(G)	-196+50	°C	U.L.L./P. ALARM CONN.	D	25	ONE		
					L.L.L. CONNECTION	E	25	ONE		
NOTES:-					SPARE OUTLET	F	100	ONE		
1. NORMAL OPERATING PRESSURE AND DESIGN PRESSURE ARE IN THE VAPOUR SPACE					PRODUCT OUTLET	G	100	ONE		
					PRODUCT INLET	H	50	ONE		
2. ATMOSPHERIC PRESSURE = 101.3 kPa(A)						I				
						J				
3. BECHTEL TO DEFINE TANK VACUUM DESIGN PRESSURE						K				
						L				
						M				
					PURGE GAS CONN.	N	50	ONE		
					MECH. L.L. GAUGE	O	250	ONE		
					PRESSURE RELIEF CONN.	P	200	ONE		
					PUMP RECYCLE CONN.	Q	75	ONE		
						R				
					PIC/P GAUGE CONN.	S	25	ONE		
					PURGE PILOT TAPPING	T	25	ONE		
					P.B.U. CONNECTION	U	40	ONE		
						V				
						W				

☒ (1) Work May Proceed. ☐ (2) Review and Resubmit. Work May Proceed Subject to Incorporation of Changes Indicated. ☐ (3) Review and Resubmit. Work May Not Proceed. ☐ (4) Review Not Required. Work May Proceed.	DATE RECEIVED	DWG. STATUS SIGNED <i>C. Ruggles</i> REF. DWG 9-30-81 BECHTEL HOUSTON
	IMPORTANT: Permission to proceed does not constitute acceptance or approval of design, calculations, analyses, test methods or materials developed or selected by the supplier and does not relieve supplier from full compliance with contractual obligations.	
PROJECT No. M8295	No. OFF: ONE	ITEM: L.P. LOX STORAGE
ITEM No.: T101		
Issue Description	By <i>BB</i> <i>5 Jun 81</i>	

PROJECT : M8295 BECHTEL

ITEM : T101 LOX STORAGE


NOTES : 1. GROSS VOLUME = 1365 M^3 MINIMUM (THIS INCLUDES 5%
VAPOUR SPACE)

NET CAPACITY = 1480 MT LOX


LOX DENSITY = 1137 KG/M^3

2. BECHTEL TO SPECIFY MECHANICAL DETAILS OF TANK
3. TANK VENDOR TO DEFINE HEAT LEAK INTO TANK, EXPRESSED AS A PERCENTAGE OF TANK CONTENTS PER DAY.
4. DETAILS OF INSTRUMENTATION ASSOCIATED WITH THE TANK AND TO BE SUPPLIED BY BECHTEL WILL BE SHOWN ON THE P & ID. (REV. O ISSUE DUE 26 JUNE 1981)
5. THE BASE OF THE INNER TANK MUST BE 3.5 METRES ABOVE GRADE FOR OPERATION OF THE LOX PRODUCT PUMP G101.
6. BECHTEL TO SPECIFY SIZE OF NOZZLE. (C)
7. THE SIZES OF NOZZLES (A) AND (P) WILL BE CONFIRMED BY BECHTEL'S TANK PRESSURE RELIEF DEVICE VENDOR AFTER TANK PRESSURE RELIEF DEVICES HAVE BEEN SPECIFIED BY APL.
8. NOZZLE SIZES REFER TO PENETRATIONS OF THE INNER TANK EXCEPT NOZZLES (C) (N) & (T) WHICH PENETRATE THE OUTER SHELL ONLY


									Project No: M8295
									No. Off: ONE
									Item: LP LOX STORAGE
0	ORIGINAL ISSUE	By	BB	5 Jun 81					Item No: T101
Issue	Description	By	Proc. App.	Date	Des. App.	Date	Proj. App.	Date	

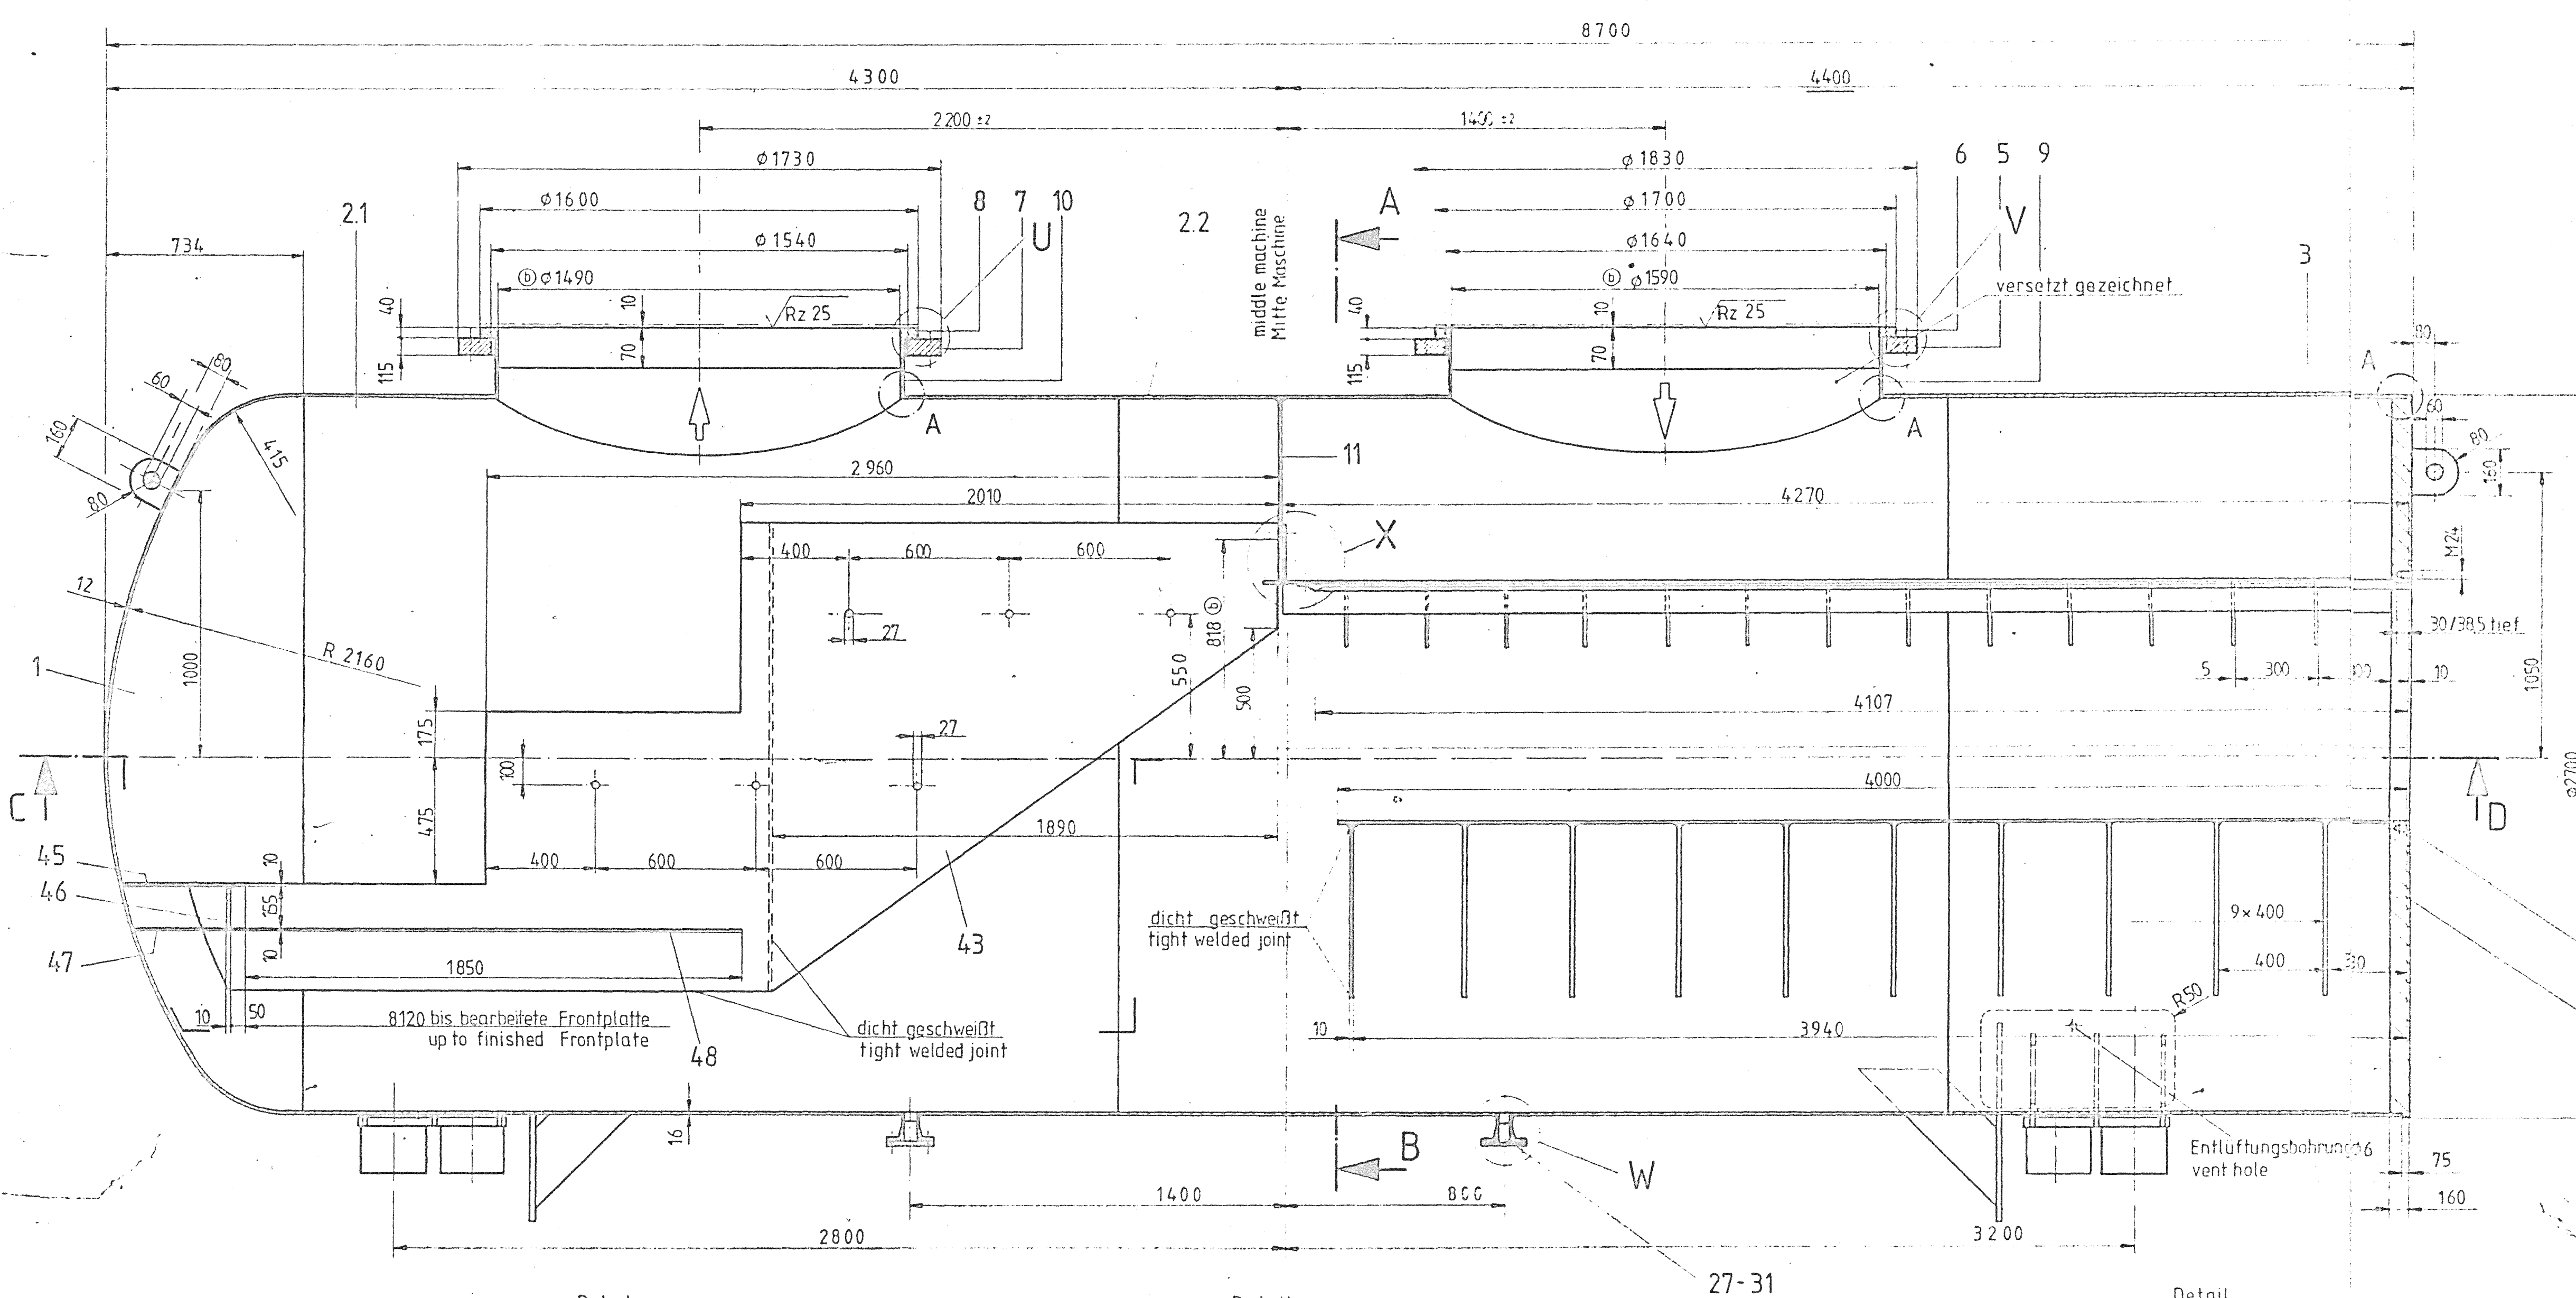Section
Schnitt E-F


Section
Schnitt A-B

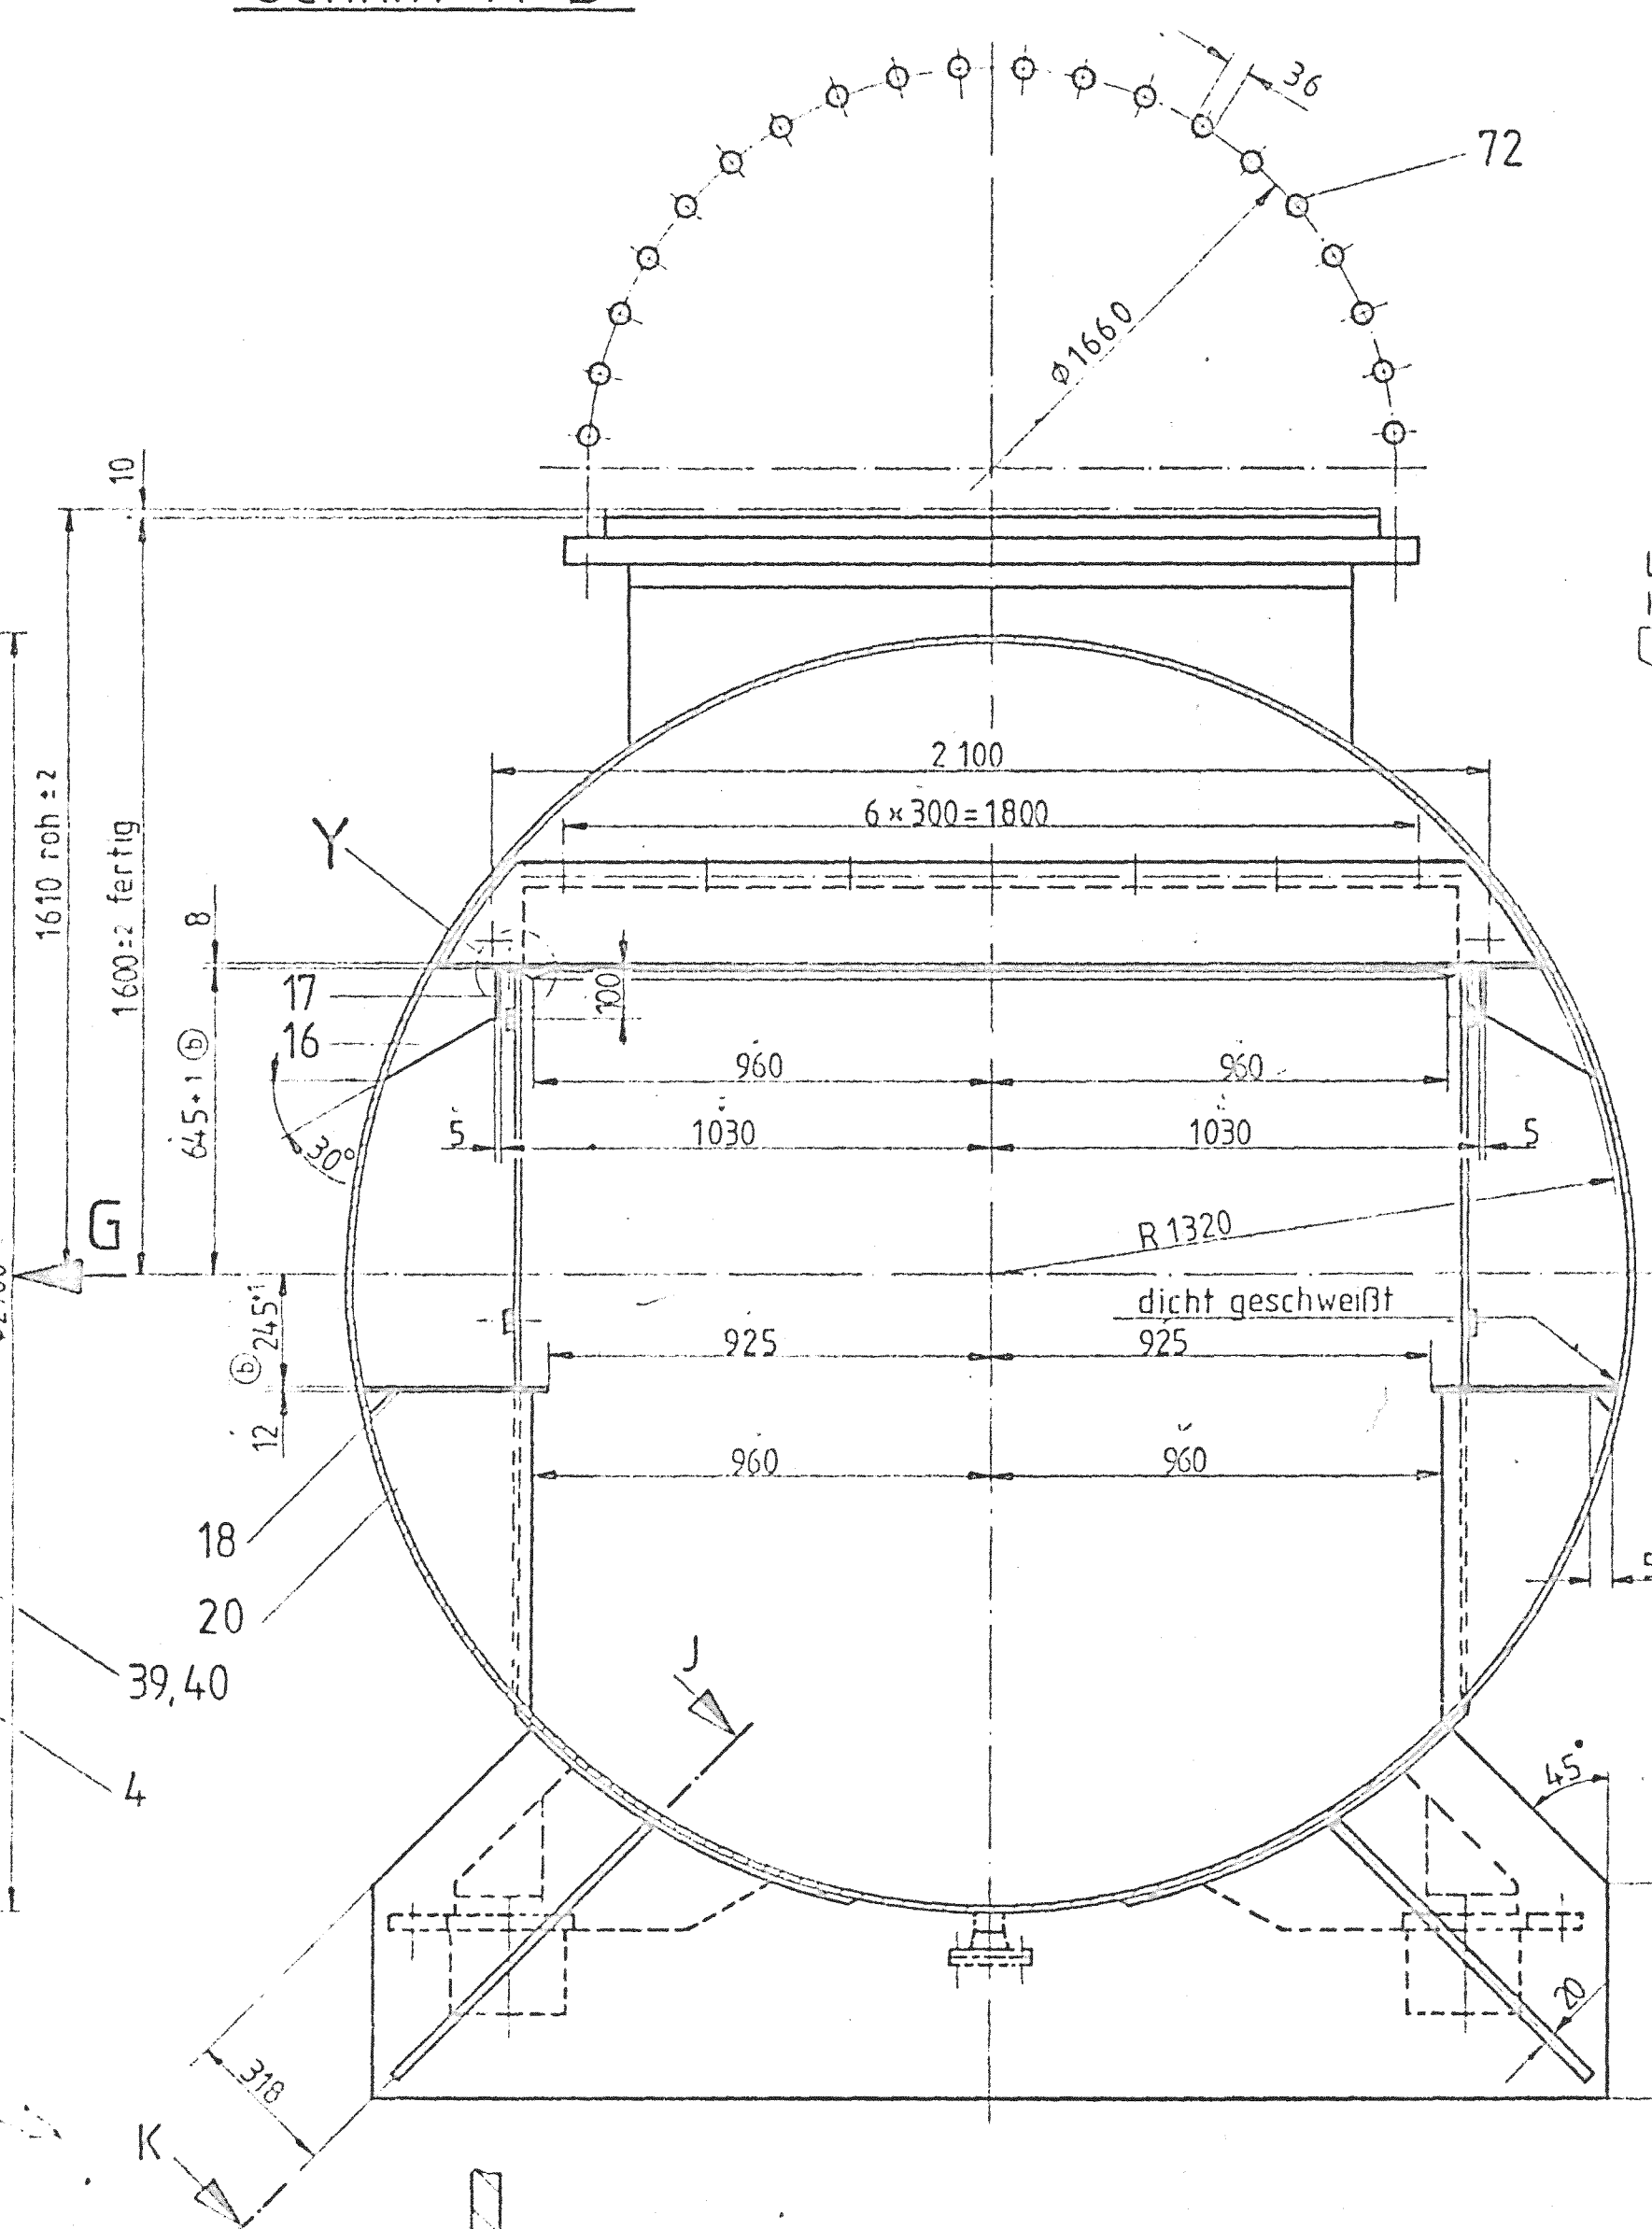


View
Ansicht G

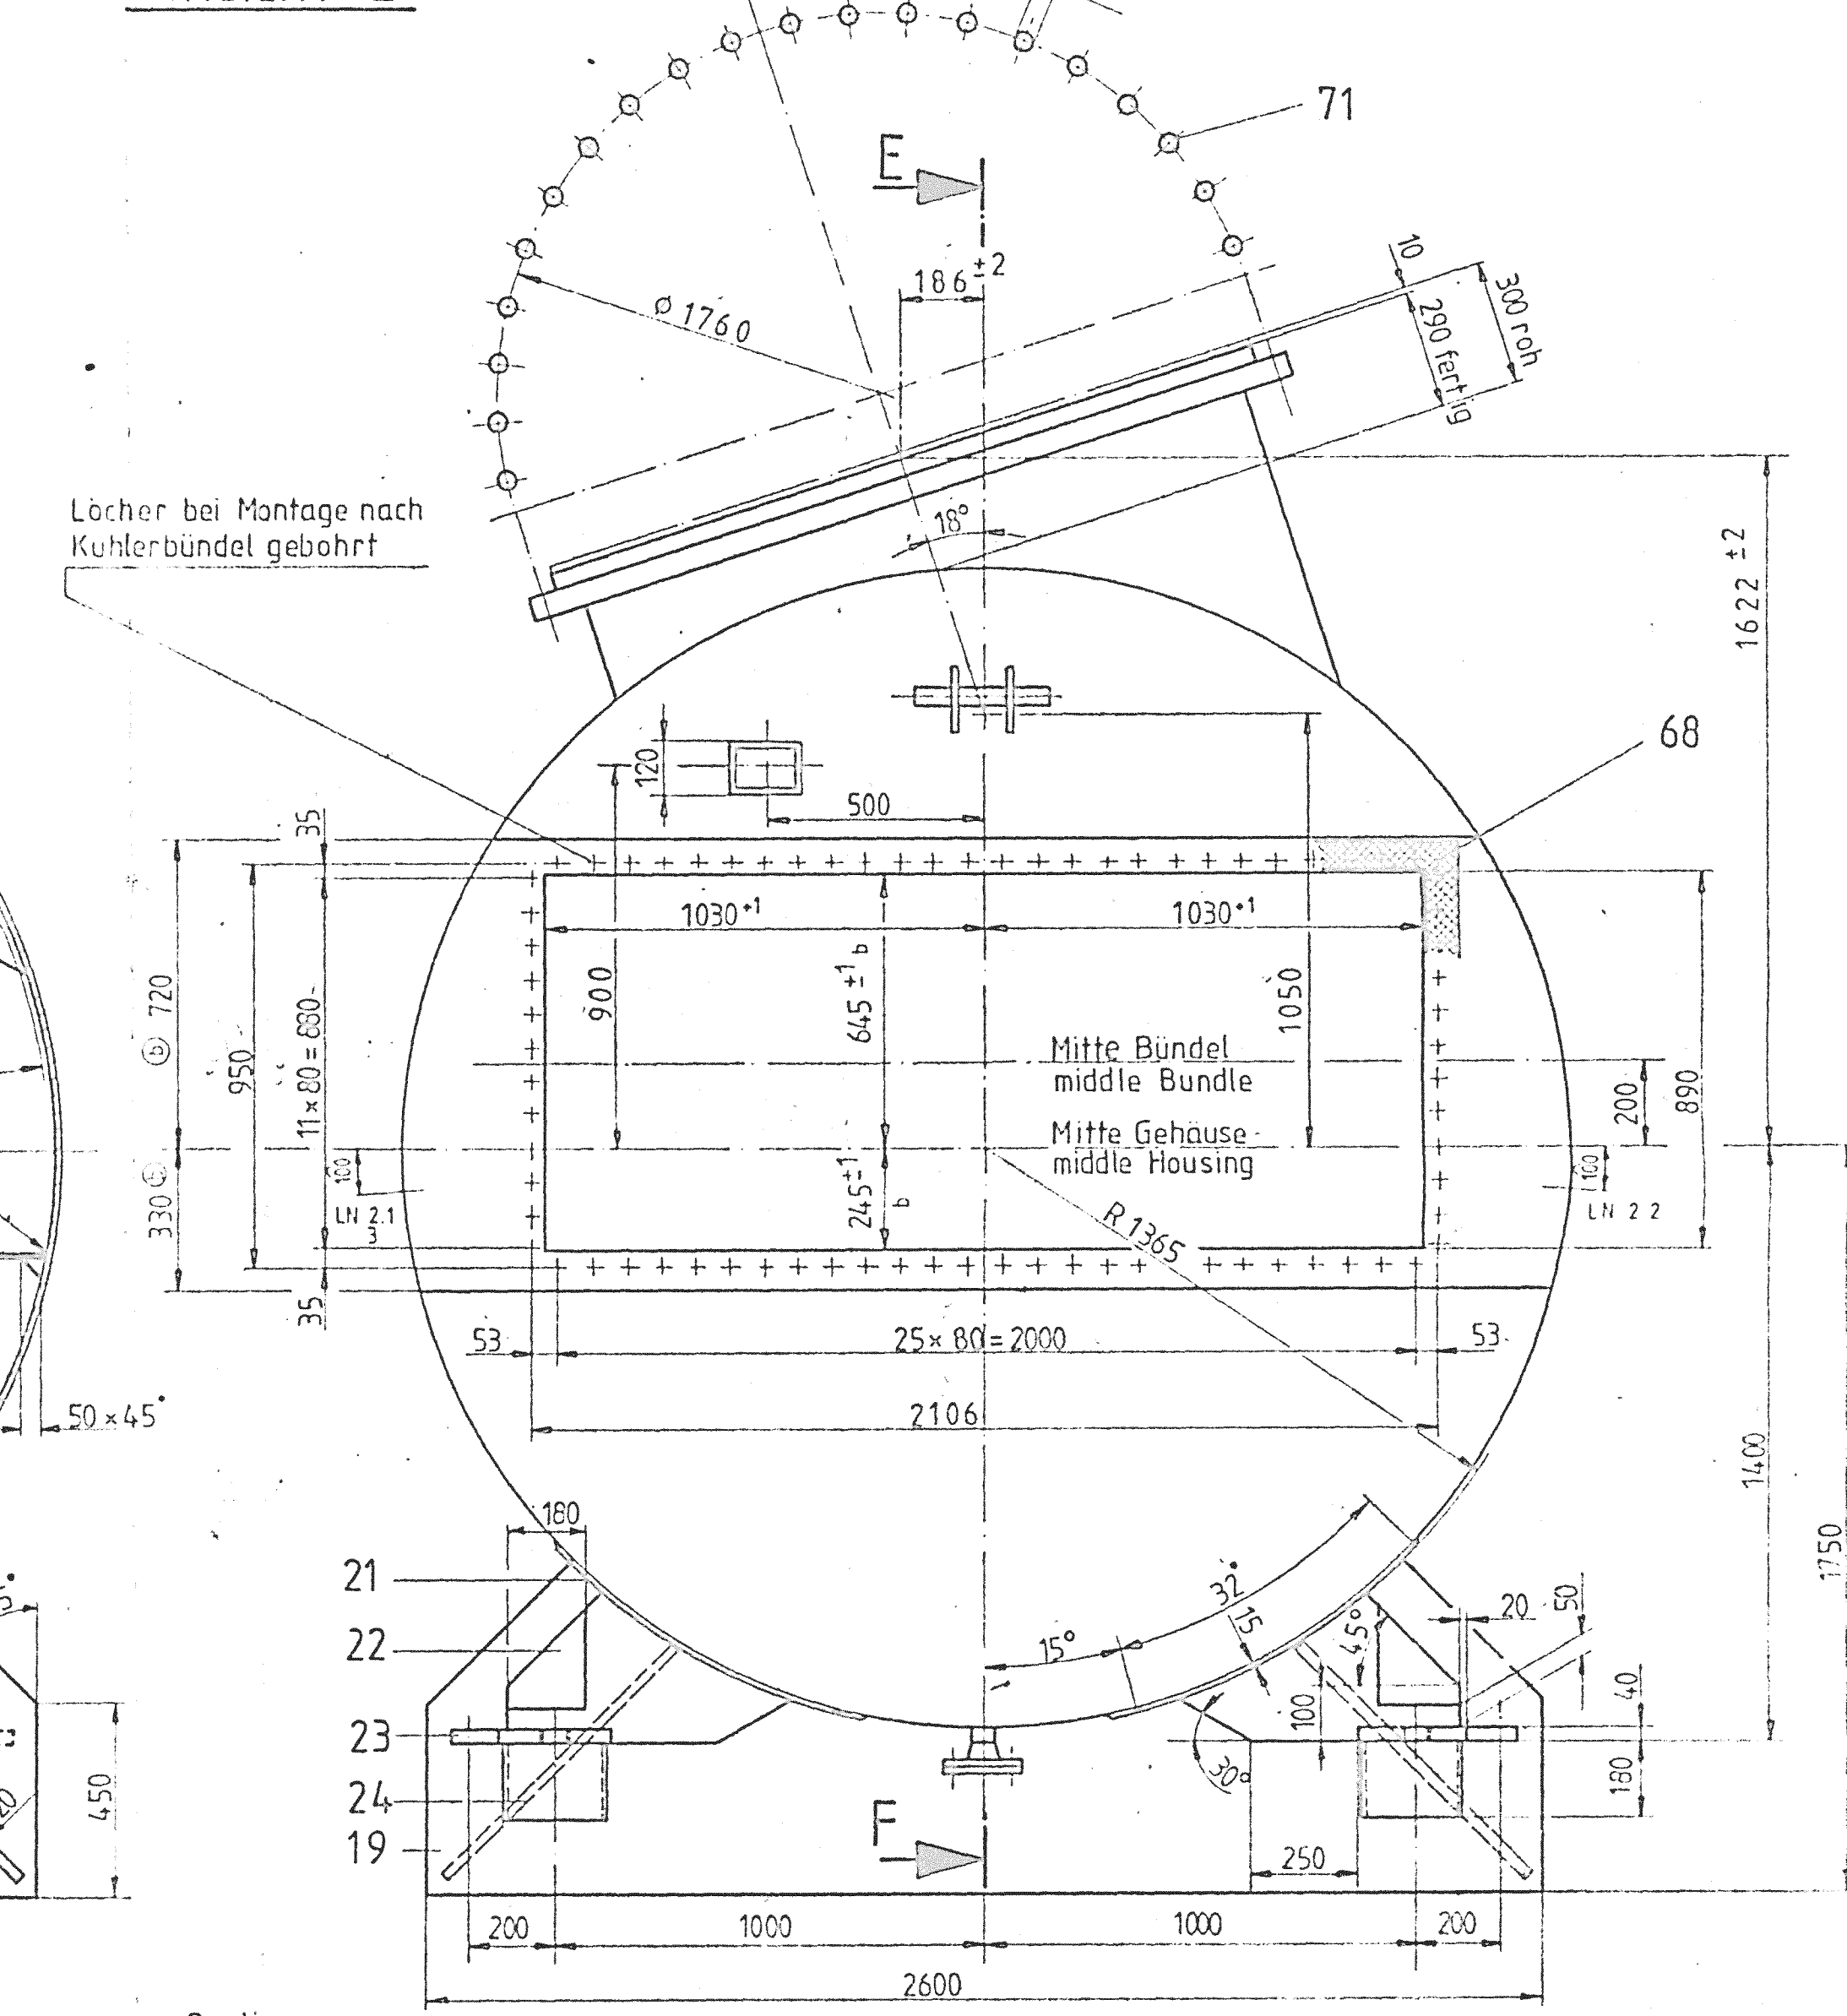


Section
Schnitt C-D

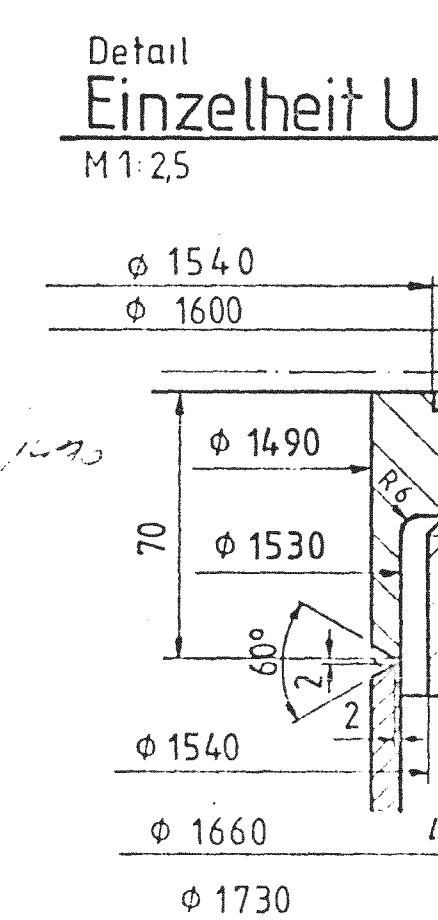


Detail
Einzelheit V

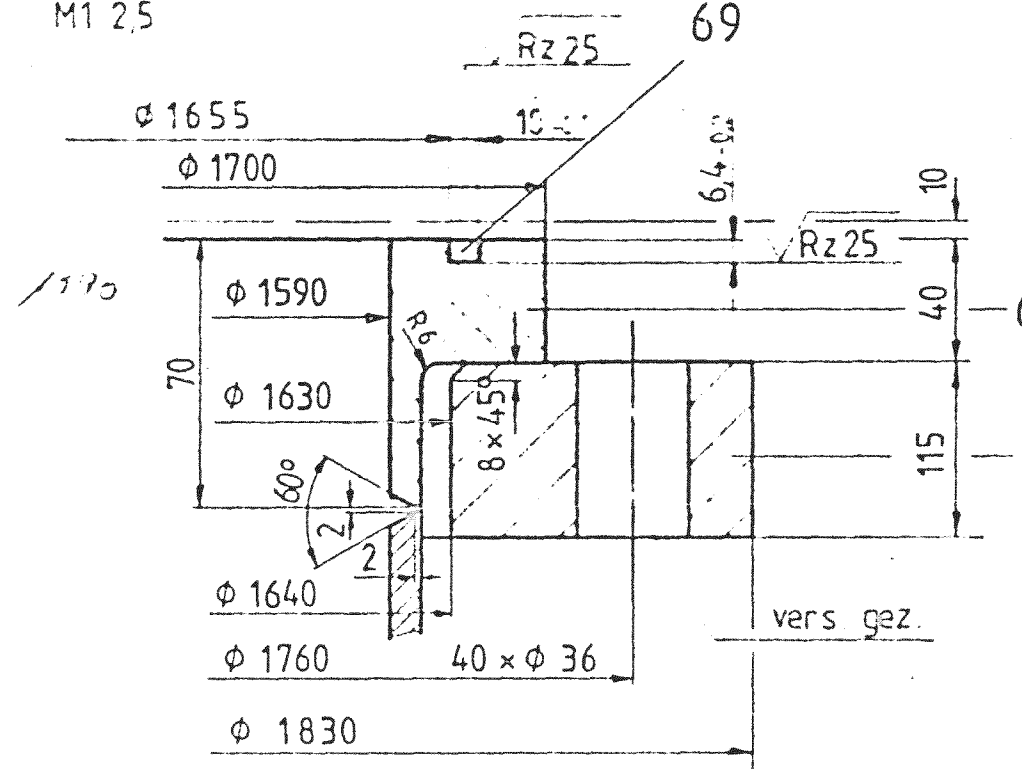


Detail
Einzelheit W

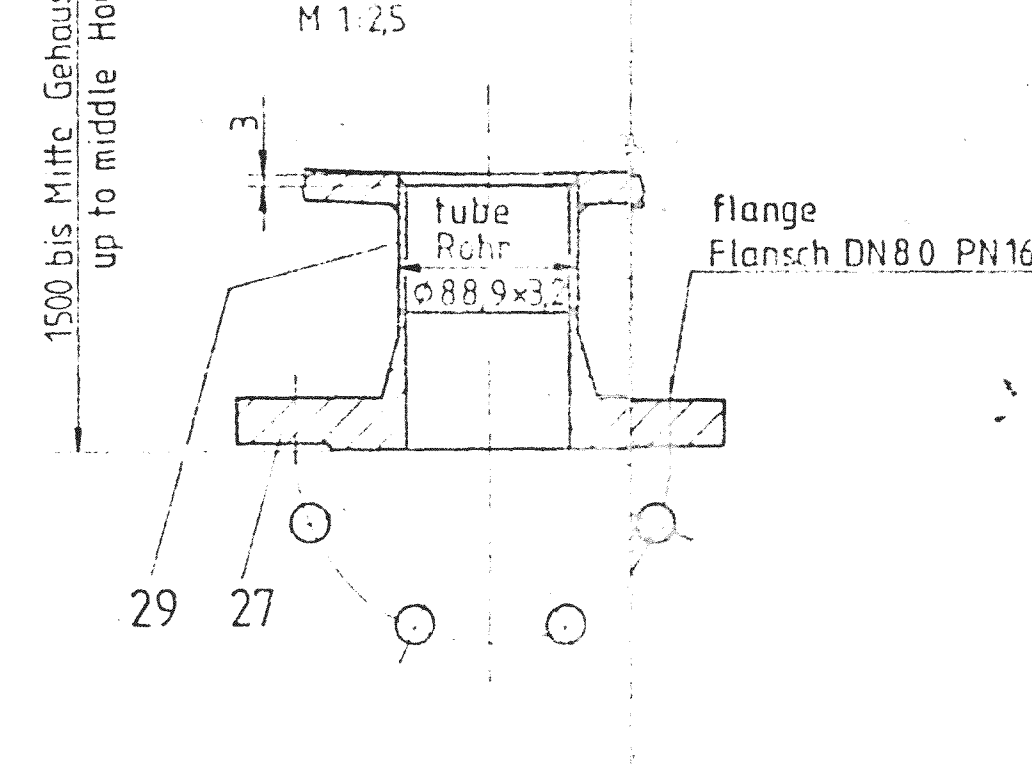


Detail
Einzelheit X
M 1:25

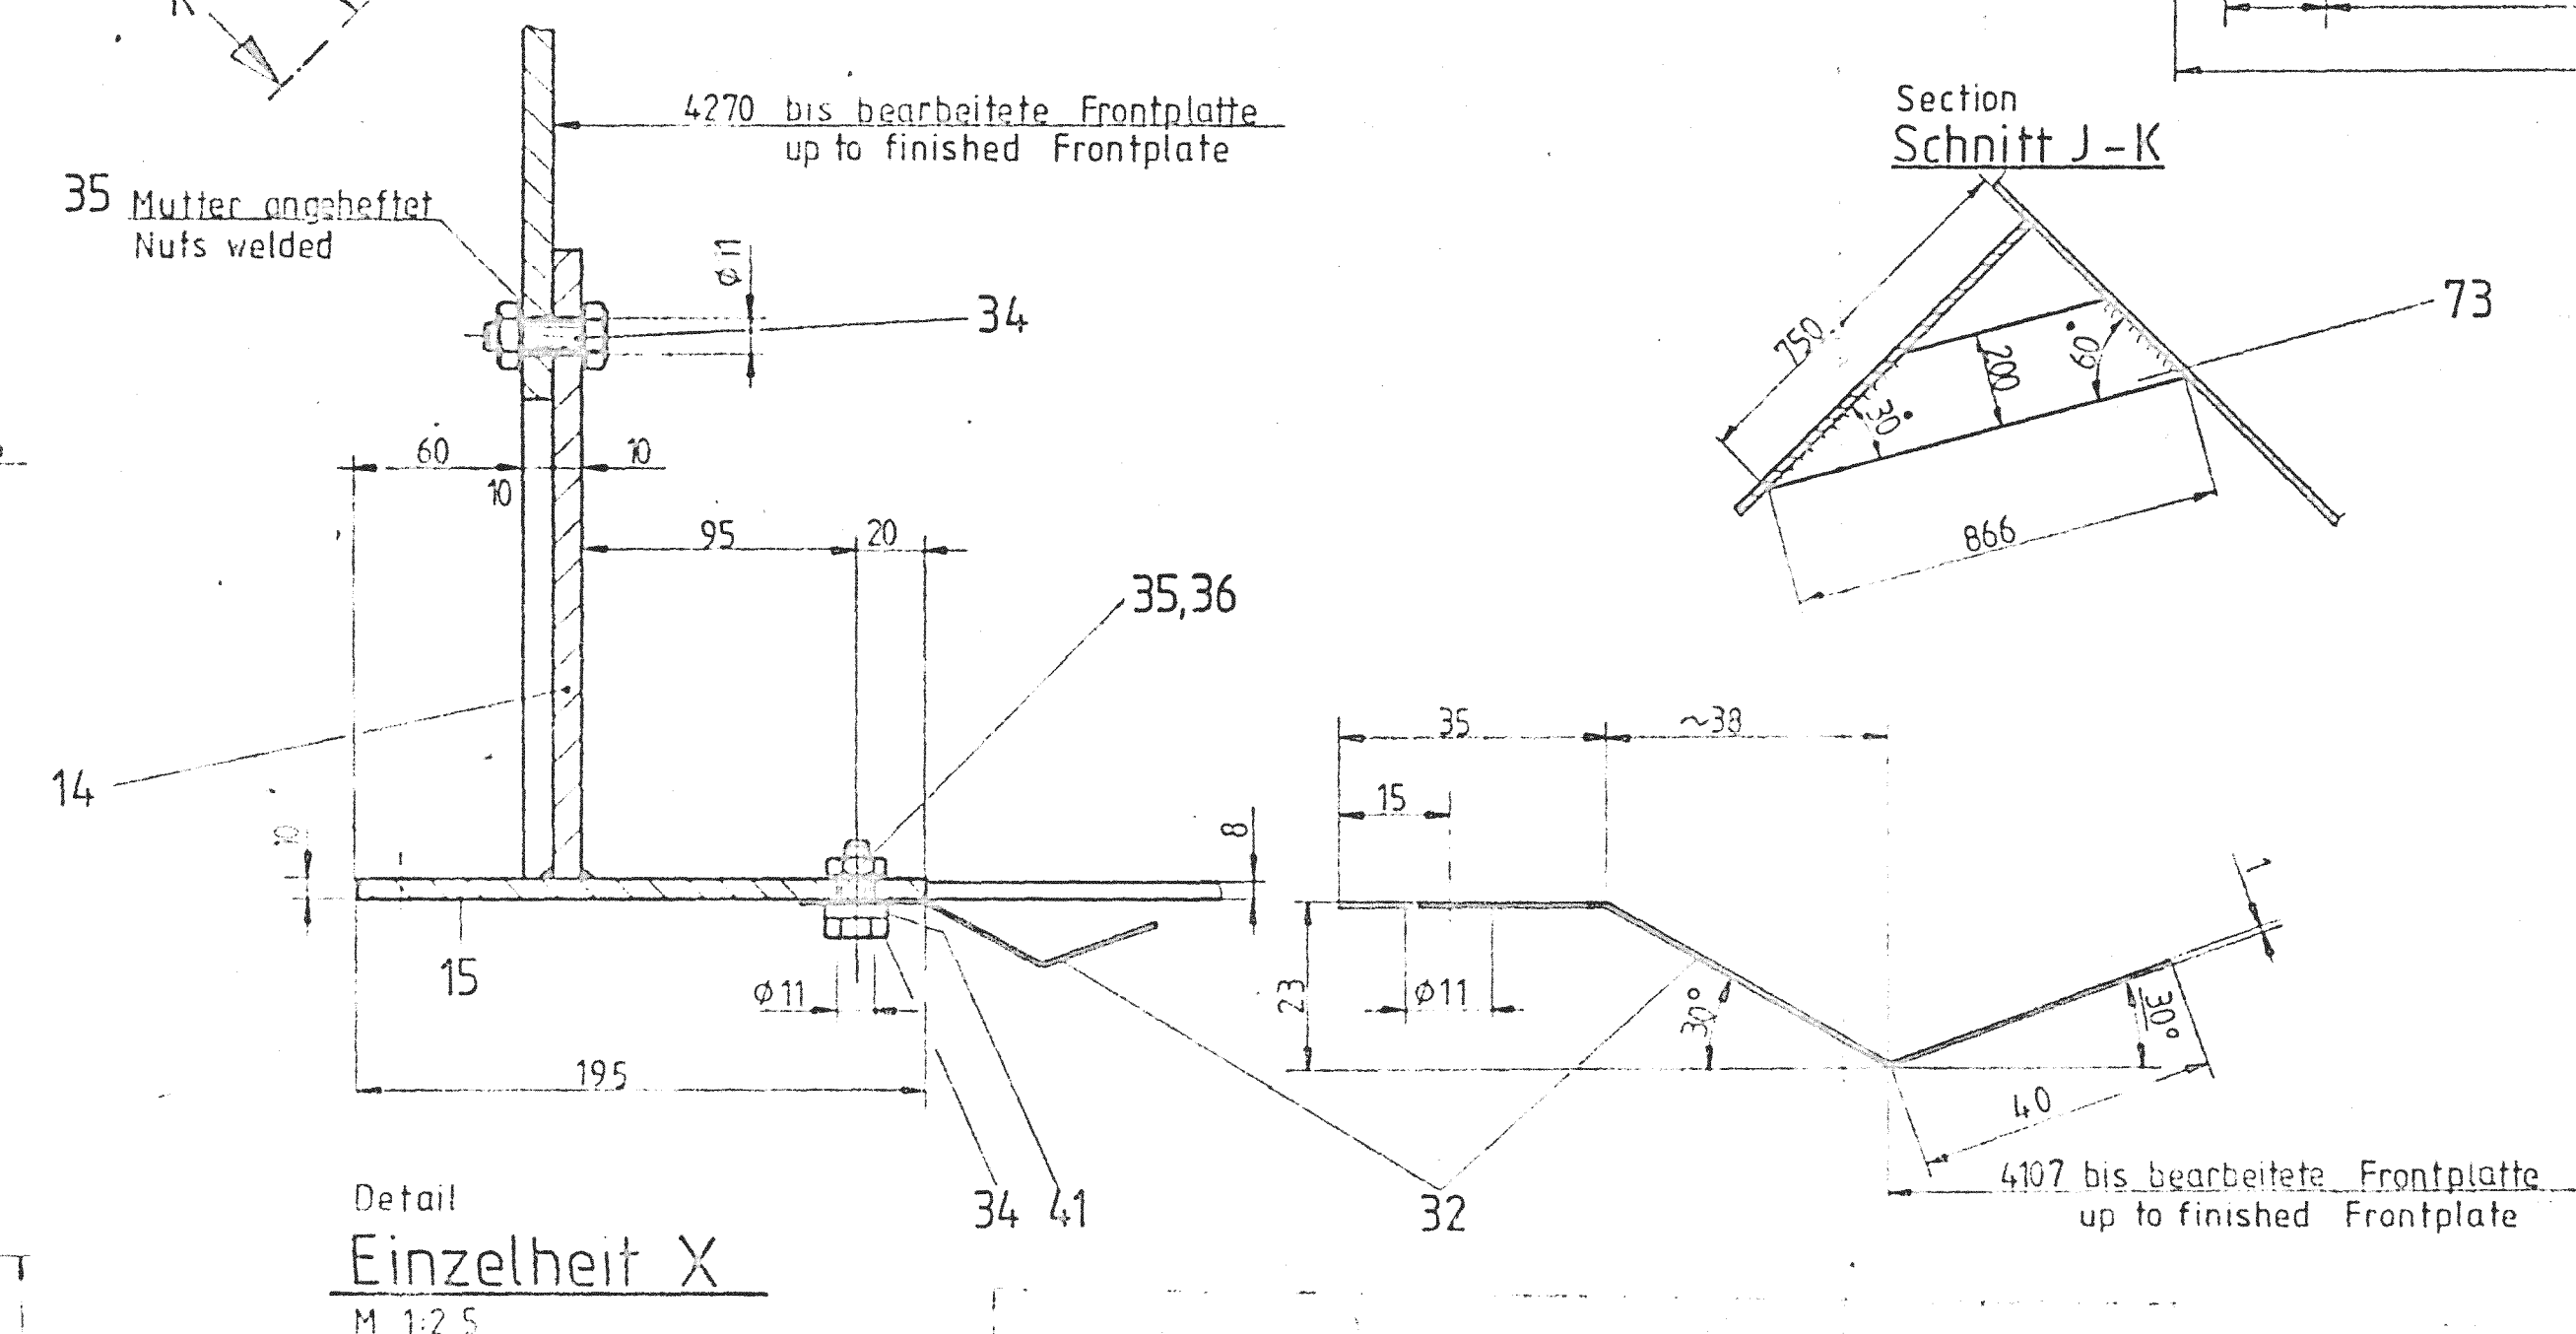


View
Ansicht H

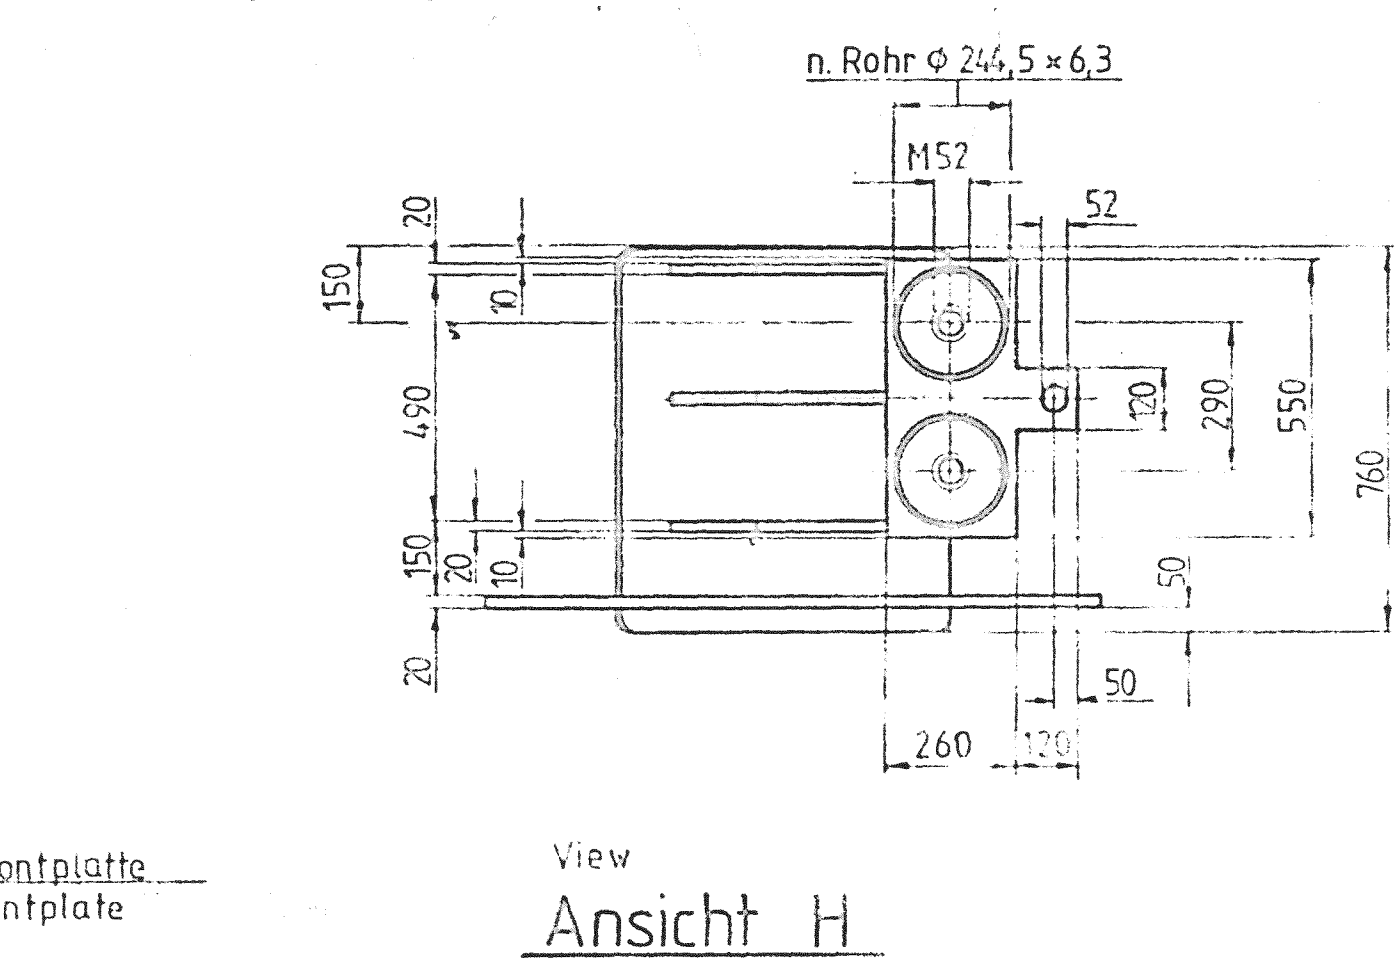

Detail
Einzelheit Z

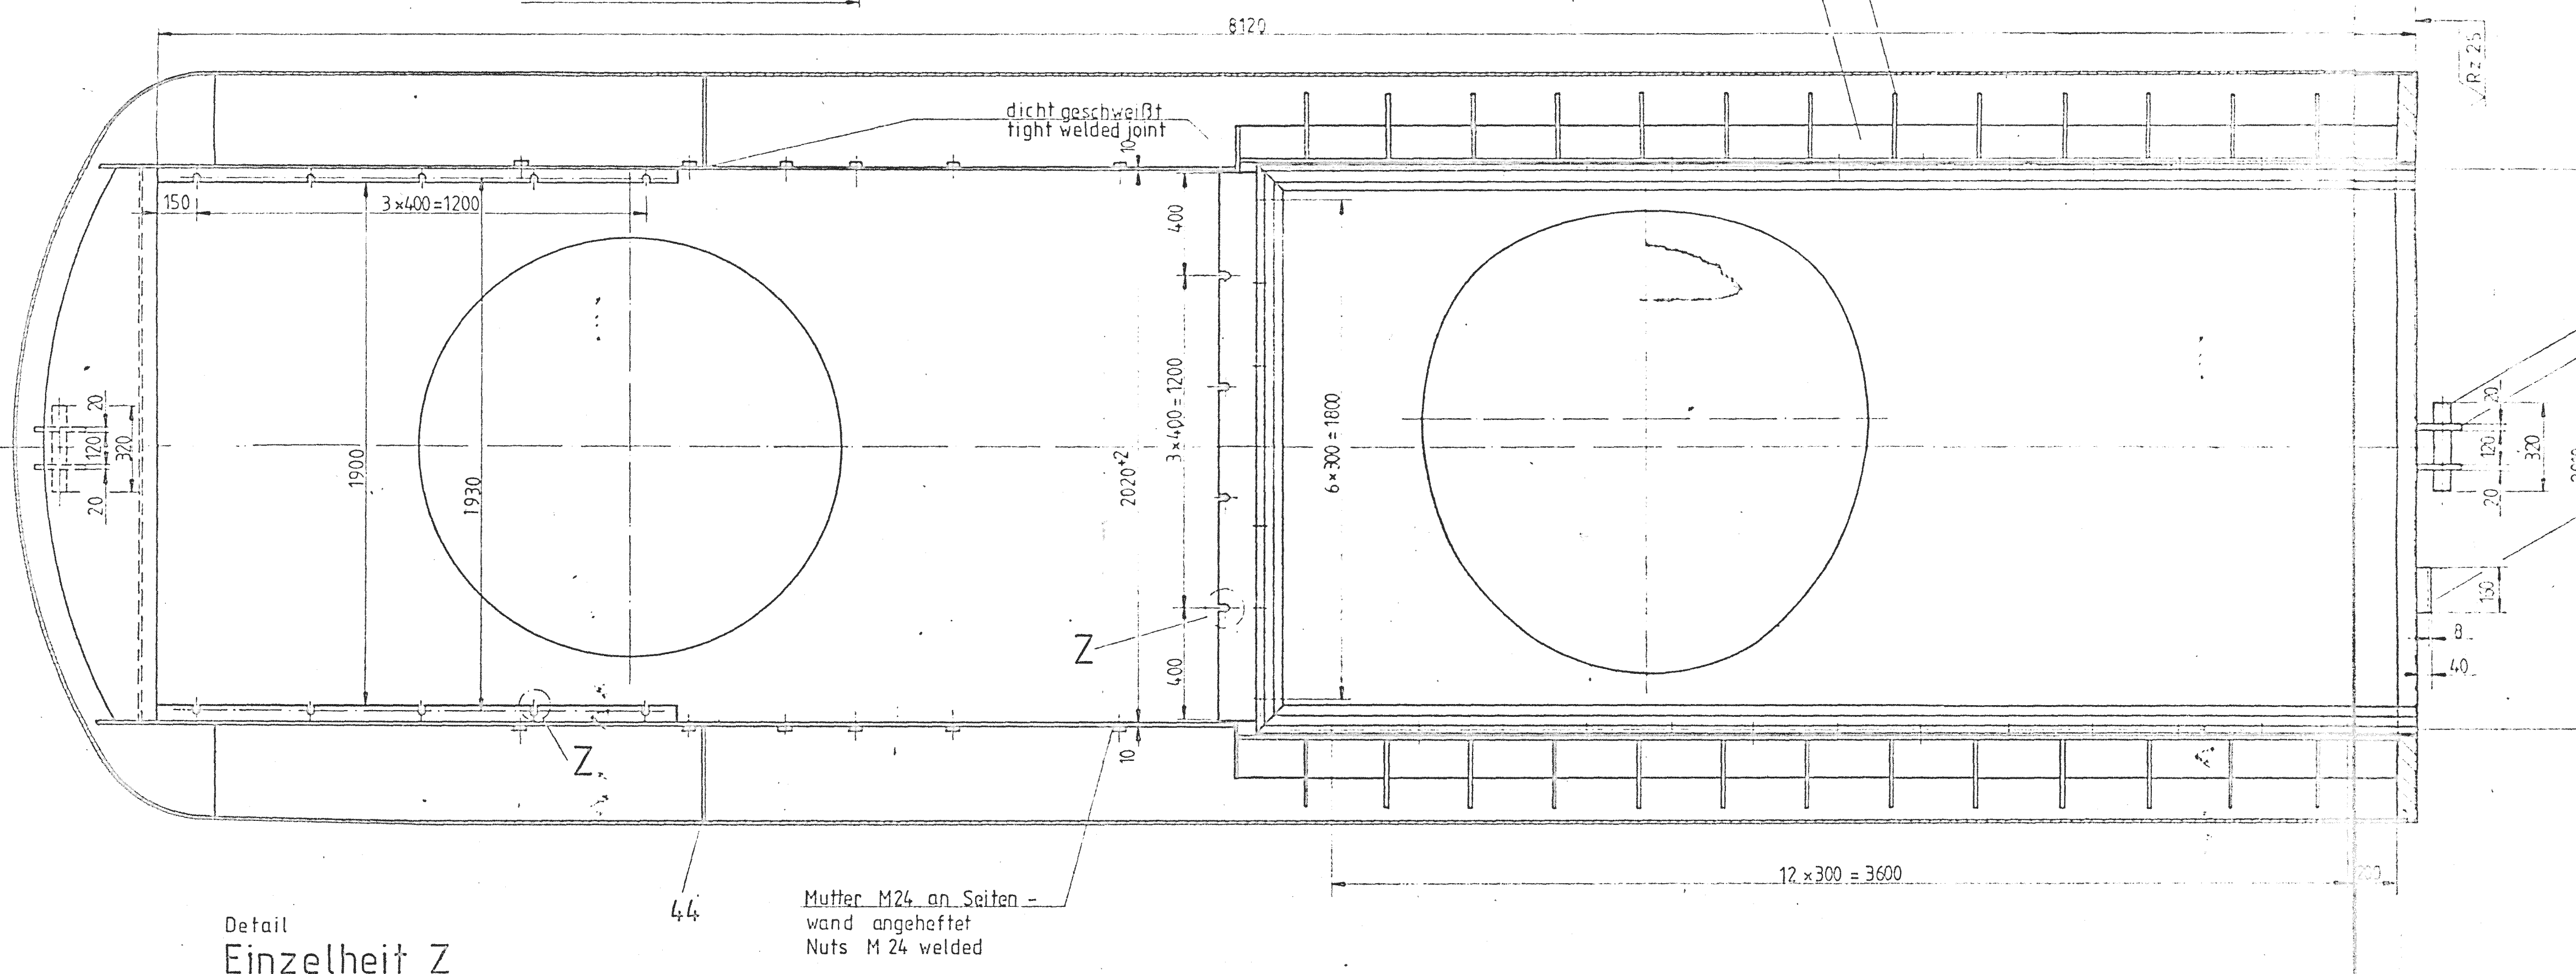


Detail
Einzelheit Y

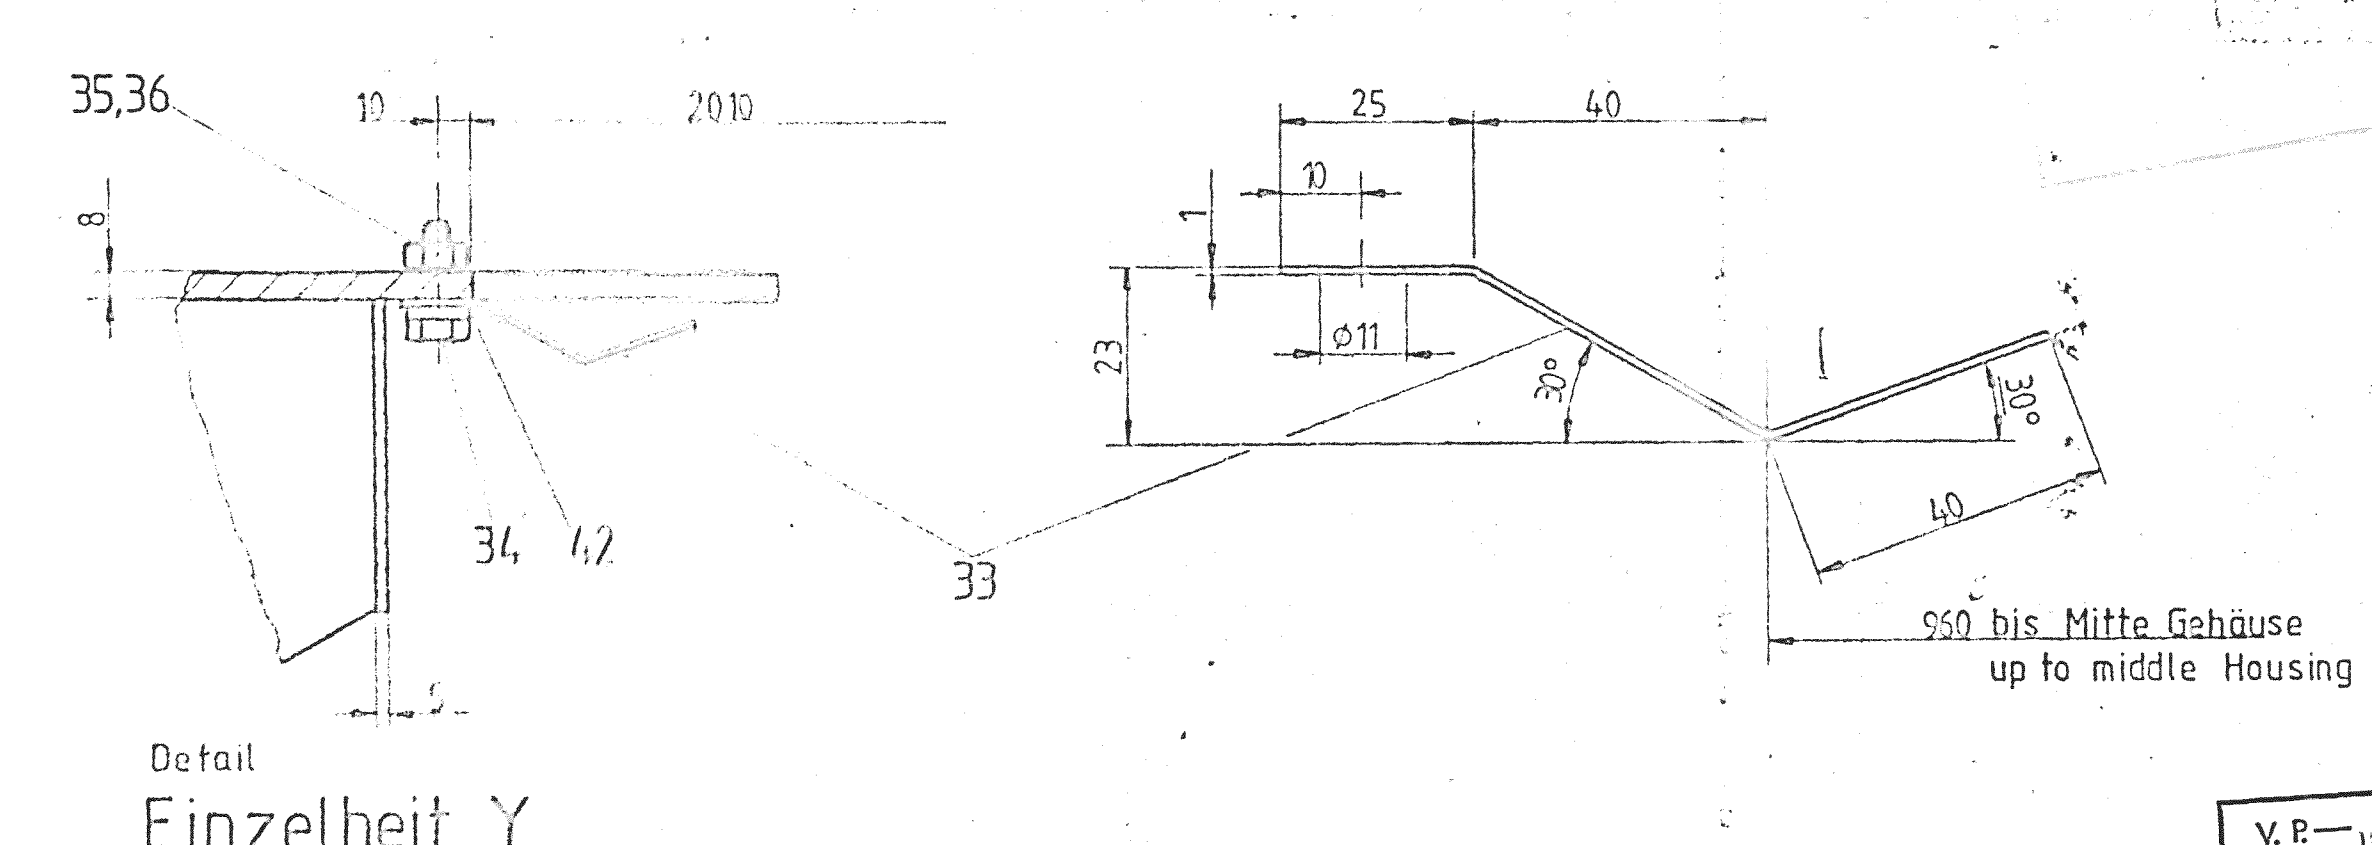

Zeichnung Nr.: 0-1102
Kom.Nr.: 1321

Schweißverfahren		E Hand, MAG, UP		Gluhen spannungsarm		Röntgen: 5%	
Method of welding		Manual electric welding MAG		Annealing stress relieving		E 51 Z 22 R 6	
		Submerged arc welding		Schweißzusatzwerkstoff		E 43 Z 3 AR 7	
				Elektrodes		Carbolit 1	
Ausnutzung der zul. Berechnungs-						S 2, P 230	
spannung in der Schweißnaht							
Welding factor		0,05					

Mehrfache Festnahmen wegen des DBH 2017				Gesamt	
1.6.07	Flucht	6	Flucht aus der Zentrale des Justizinsp. 601/17	Geschäftsnummer W. 0131055	6
1.6.07	Flucht	6	Flucht vom Polizeiposten 601/17	Gruppe 601/17	6
Unter	Name	Anschrift	Erreichte	Cooler	Stufe 1
Datum	20.08.17	17.08.17		ZW	Kühler
Name	12.08.17	17.08.17			Stufe 1
DBH 01	601/17	601/17			
	17	17			
15142815				6-55-1	

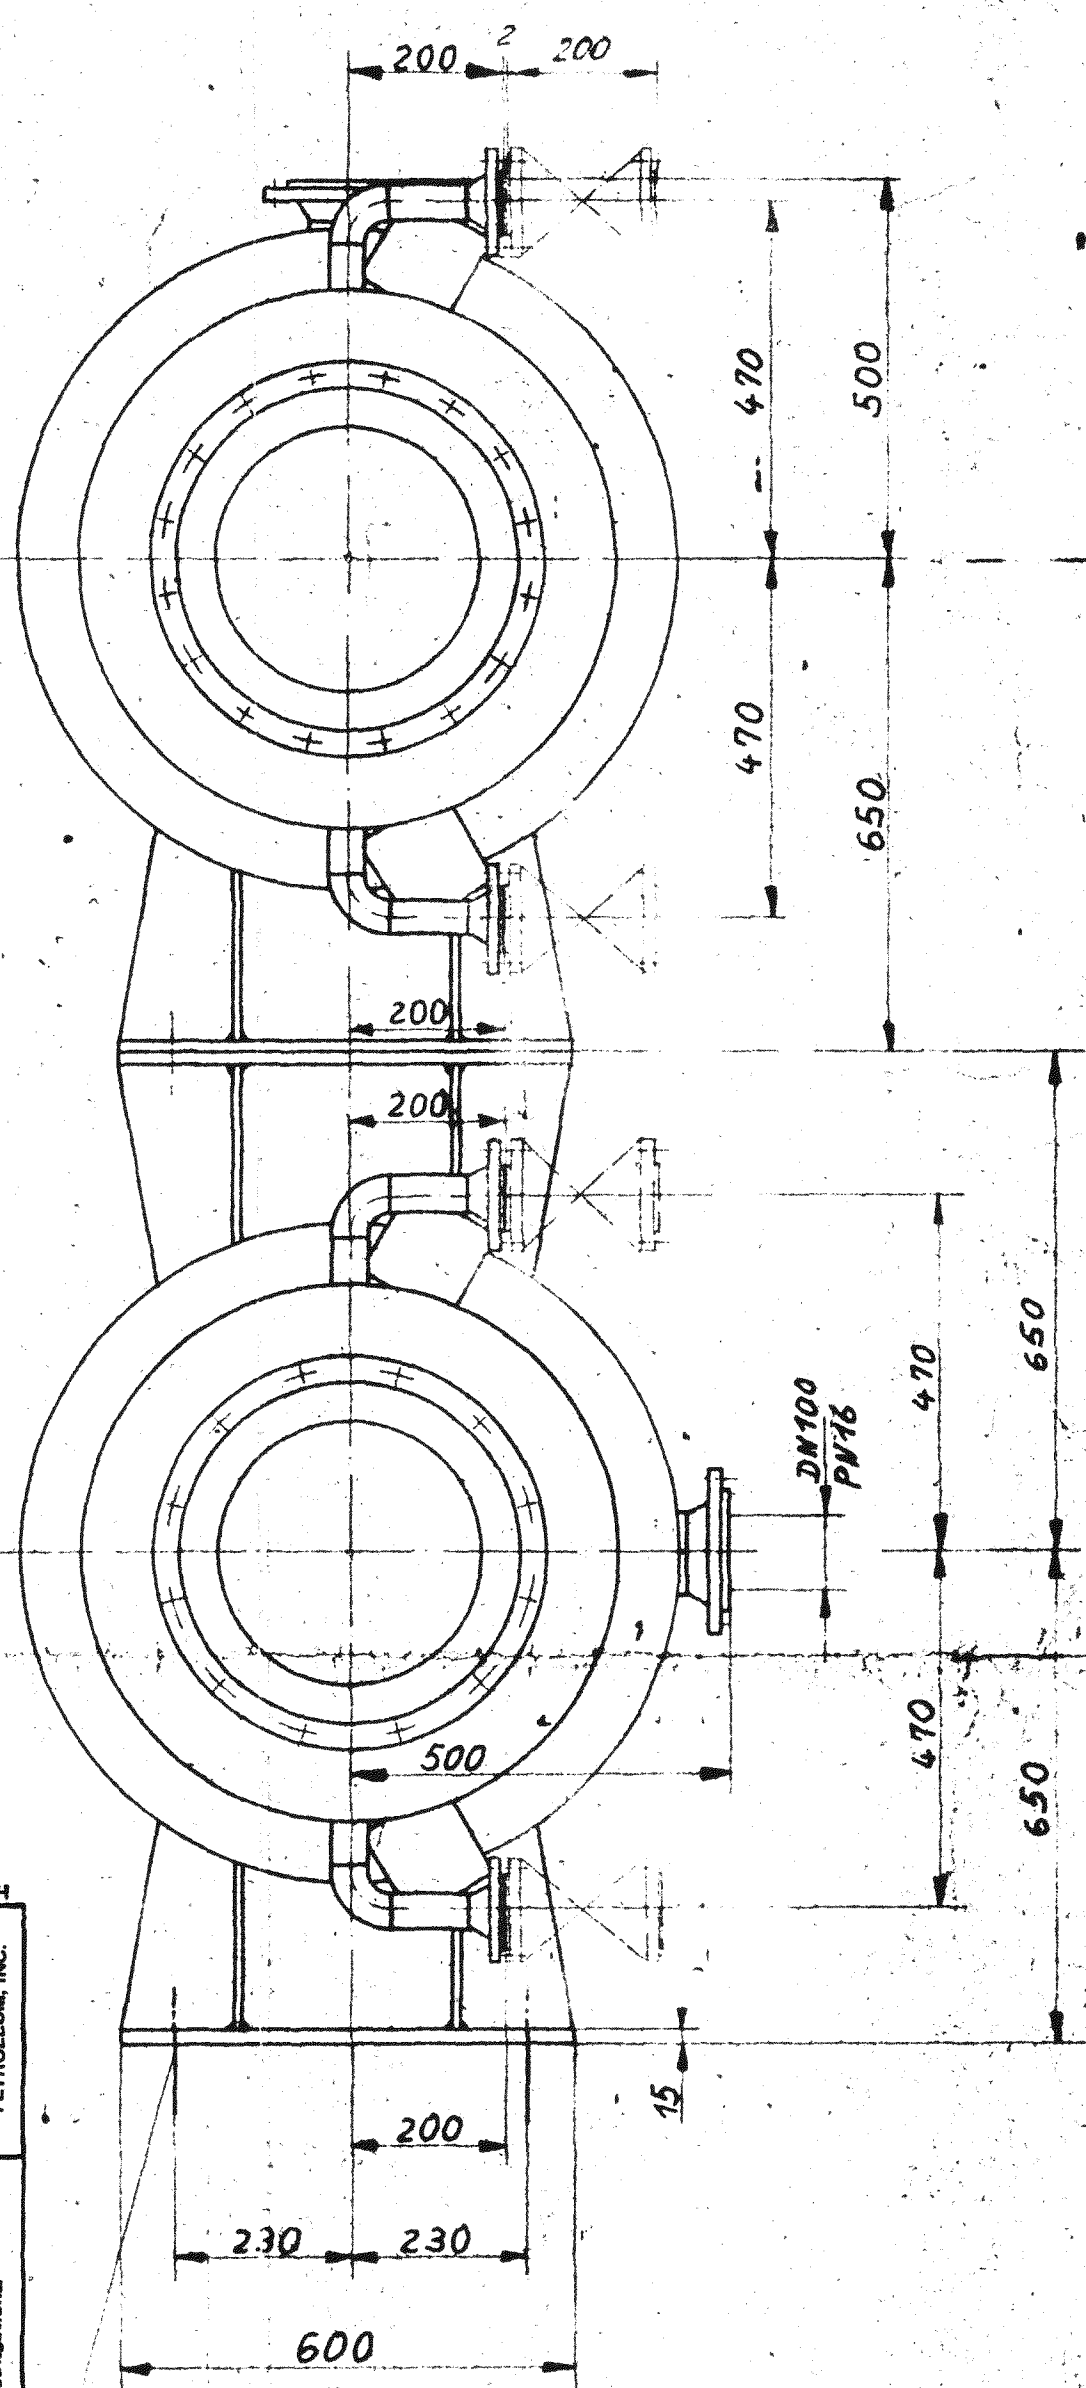

☒ (1) Work May Proceed. ☒ (2) Review and Re-submit. Work May Proceed. ☐ (3) Review and Re-submit. Work May Proceed. ☐ (4) Review and Re-submit. Work May Proceed.	DATE RECEIVED 7/15/83 IMPORTANT: Permission to proceed does not constitute approval of design, calculations, test methods or materials developed or selected by the supplier. The contractor shall be responsible from full compliance with contract specifications.	DWG. STATUS SIGNED <i>H. H. H. H.</i> DATE 7/15/83 BECHTEL PERFORM INC.
--	--	--

 MANNESMANN DEMAG	Ident-Nr.	<u>14586815</u>	Anzahl	Fürtrag	Belt
	Eingetragen aus			1	1

Ziffer	Ziffer (kannst vor)	Änderung		Tag		Name		Zugehörige Zeichnungen	
Jahr	1981	Tag	Name	HALBERG Für diese Zeichnung behalten wir uns alle Rechte vor. Obertafel-Reihe 2 DIN 3141 zul. max. Rauhiefe in µm ~~~~~ beiblag 100 25 63 1			Entstanden aus		
Gezeichnet	3.12	Schneider					Entwurf für		
Geprüft	5.182	H. L. Meyer		Erstellt durch			Halb- oder Werkstatt		
Gesehen									
Fertigung							Fertig-Gewicht		
Normengeprüft							Modell-Nr.		
Maßstab	Sauerstoffkühler O ₂ - COOLER Typ R 355 x 500 i S 105 W-S 12218/19.5						Stufe I u II stage		
1:10							B700.52195		

Equipment	Material	Type	Additional	Dimension
C-5001	Alloy	Cold Box Column	No Data	Volume with Same Material
C-5002	Alloy	Cold Box Column	No Data	Volume with Same Material
C-6401	CS-1054C	Cold Box Column		3.150 M ID x 8.938 M H
C-6402	CS-1054C/CS-1055C	Cold Box Column		3.150 M ID x 11.828 M H
D-5011 A/B	CS	Dryer Drum		2.75 M x 2.6 M
D-6401A				
D-6401B				
D-6402	inner SEW 680-70* 8 NI 9	Double walled Drum		Outer (2.5 M OD, 8.362 M H) Inner (2.2 M, 6.58 M H)
D-6403	inner SEW 680-70* 8 NI 9	Double walled Drum		Outer (2.5 M OD, 4.9 M H) Inner (2.2 M, 3.98 M H)
D-6404		Cold Box drum		
D-6414				
D-6415	CS	Condensate Drum		0.6 M ID x 0.850 M H
D-6416	CS	Condensate Drum		0.6 M ID x 0.850 M H
D-6417 A/B		Dryer Drum		
E-212				
E-5001	Lined CS	Drum		1.6 M ID x 14.3 M H
E-5002 A/B	Aluminum	Cold Box Exchanger		
E-5003	Alloy	Cold Box Exchanger		
E-5007	Alloy	Cold Box Exchanger		
E-5015	GRP	Drum		1.7 M ID 8 M H
E-5021				
E-5025				
E-5031		Electrical Heater	275 kw	
E-5034		Electrical Heater	275 kW	
E-5083		Plate and Frame Heat Exchanger		
E-6401	SA-516-70	Drum		3.35m ID x 9.951 M H
E-6401 A-D	Aluminum	Cold Box Exchanger		
E-6401 E-H	Aluminum	Cold Box Exchanger		
E-6403	SB-211	Cold Box Exchanger		
E-6404 A-D	SB-209	Cold Box Exchanger		
E-6405	SA-53/249-304	Shell and Tube Heat Exchanger		
E-6406	SA-53/249-304	Shell and Tube Heat Exchanger		
E-6407	CS/SS	Vaporizer		
E-6409	SA-283/249/304	Vaporizer		
E-6410	SB-209	Cold Box Exchanger		
E-6412	SB-209	Cold Box Exchanger		
E-6414	Aluminum	Air Vaporizer		
E-6415	Aluminum	Air Vaporizer		
E-6418	Aluminum	Air Vaporizer		
E-6419	Aluminum	Air Vaporizer		
E-6420	Copper	Air Vaporizer		
E-6417		Electrical Heater	54kw	
E-6421		Drum		
E-6422				
E-6423		Electrical Heater	1000 kW	

E-6425		Shell and Tube Hx		
E-6426				
E-6442		Drum		
E-7405	SA-516-60	Plate and Frame Heat Exchanger		
F-6401	GRC/ASTM A-240 304 SS	Double walled tank		H) Inner (12.58 M ID x 11.1 M H)
F-6402	GRC/ASTM A-240 304 SS	Double walled tank		H) Inner (15.270 M ID x 17.664 M H)
G-5001 A/B		Pump		
G-5002 A/B		Pump		
G-6401RA/RB		Circulation Pump		
G-6402A/B		Liquid Oxygen Pumps		
G-6403A/B		Liquid Nitrogen pumps		
G-6406				
G-6407A/B				
G-6407A/B				
G-6408				
H-6401A				
H-6401B				
K-5001				
K-5001-E1	CS	Shell and Tube Heat Exchanger		
K-5001-E2	CS	Shell and Tube Heat Exchanger		
K-5001-E4 A/B	CS	Shell and Tube Heat Exchanger		
K-5001-E5		Electrical Heater	14 kW	
K-5001-E5-VF		FAN		
K-5001-G1 A/B		Lube Oile Pump		
K-5001-V1 A/B		Lube Oile Filer		
K-5002		Compressor and Motor	1053 kW	
K-5002-D1		Drum		
K-5002-D3		Drum		
K-5002-E1		Shell and Tube Heat Exchanger		
K-5002-E2		Shell and Tube Heat Exchanger		
K-5002-E3		Shell and Tube Heat Exchanger		
K-5002-E5A/B		Shell and Tube Heat Exchanger		
K-5002-G1 A/B		L.O Pump		
K-5002-V1 A/B		L.O Filter		
K-5004 A/B		Turbine		
K-5004-A-E1		Electrical Heater	3 kW	
K-5004A-E2A/B		Shell and Tube Hx		
K-5004A-G1 A/B		Lube Oil Pump		
K-5004A-V1A		Lube Oil Filter		
K-5004A-V1B		Lube Oil Filter		
K-5004A-V2		Lube Oil Filter		
K-5004A-V3		Lube Oil Filter		
K-5004-B-E1		Electrical Heater	3 kW	
K-5004B-E2A/B		Shell and Tube Hx		
K-5004B-V1 A/B		Lube Oil Filter		
K-5004B-V2		Lube Oil Filter		
K-5004B-V3		Lube Oil Filter		
K-6401	CS	Compressor	138000 M3	

K-6401-E1	CS	Shell and Tube Heat Exchanger	
K-6401-E2	CS	Shell and Tube Heat Exchanger	
K-6401-E3	CS	Shell and Tube Heat Exchanger	
K-6401-E4A	CS	Shell and Tube Heat Exchanger	
K-6401-E4B	CS	Shell and Tube Heat Exchanger	
K-6401-E5A/B		Electrical Heater	12 kw
K-6401-E6			
K-6401-G1A/B		L.O Pump	
K-6401-GT1A		Turbine	22.5 kw
K-6401-V1A		Lube Oile Filer	
K-6401-V1B		Lube Oile Filer	
K-6402		Oxygen Compressor	
K-6402-E1		Shell and Tube Heat Exchanger	
K-6402-E2		Shell and Tube Heat Exchanger	
K-6402-E3		Shell and Tube Heat Exchanger	
K-6402-E4		Shell and Tube Heat Exchanger	
K-6402-E5A/B		Shell and Tube Heat Exchanger	
K-6402-E6		Electrical Heater	9 kw
K-6402-V1A/B		Lube Oile Filer & 4 L.O Pumpss	
KM-5001		Motor	4300 kW
KM-5001-E1			
KM-5002			
KM-6401		MOTOR	15000 kW
KM-6402		MOTOR	3500 kW
PG-6401A		Expander Generator	434.5 kw
PGT-6401A		Expander Turbine	24700 m3
PGT-6401A-E1		Electrical Heater	6 kw
PGT-6401A-E2		Shell & Tube HeatX	
PGT-6401A-G1A		Aux Lube Oil Pump	
PGT-6401A-G1B		Aux Lube Oil Pump	
PGT-6401A-V1A		Lube Oil Filter	
PGT-6401A-V1B		Lube Oil Filter	
PG-6401B		Expander Generator	434.5 kw
PGT-6401B		Expander Turbine	24700 m3
PGT-6401B-E1		Electrical Heater	6 kw
PGT-6401B-E2		Shell & Tube HeatX	
PGT-6401B-V1A		Lube Oil Filter	
PGT-6401B-V1B		Lube Oil Filter	
V-5001		Inlet Filter	
V-5015		Filter	
V-5015-1		Filter	
V-6401K1	CS	Inlet Filter	5.5 kW
Y-5003		Vent Siencer	
Y-5004		Vent Silencer	
Y-5006		Vent Silencer	
Y-5008		Vent Silencer	
Y-5011		Vent Siencer	
Y-5012		Vent Silencer	
Y-6401		Vent Silencer	
Y-6402		Vent Silencer	

Y-6404		Vent Siencer		
Y-6405-E1				
Y-6405-G1				
Y-6406-E1				
Y-6406-G1				
Y-6409-E1		Vent Silencer		
Y-6409-G1		Pump		
Y-6410		Vent Silencer		
Y-6411		Vent Silencer		
Y-6412		Vent Silencer		
Y-6413		Vent Silencer		
Y-6490		Vent Silencer		